


Oversight / NHS	
FHWA REGION VIII OVERSIGHT?	■ NO □ YES
NATIONAL HIGHWAY SYSTEM?	■ NO □ YES

CRIPPLE CREEK & VICTOR GOLD MINING COMPANY


RIGHT-OF-WAY PLAN OF PROPOSED REALIGNMENT
STATE HIGHWAY NO. 67 / VICTOR
TELLER COUNTY

Related Projects:	
P. E. UNDER PROJECT:	Project Number
	Project Code
R.O.W. Projects:	
	R.O.W. Project Description


CONVENTIONAL SIGNS

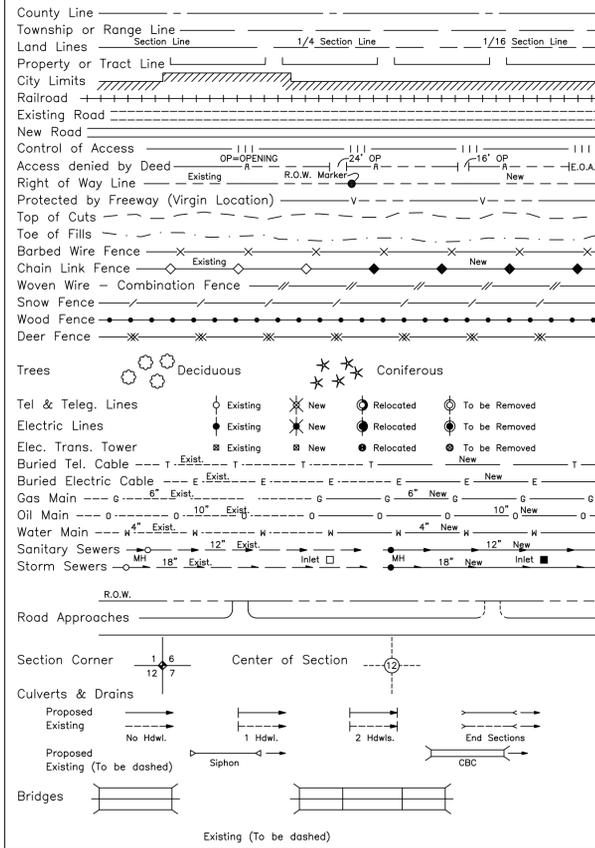

Basis of Bearing: A bearing of N 87°13'44" W along the South line of the SE 1/4 of Section 24, T. 15 S., R. 70 W. of the 6th P.M., monumented at each end with a 3-1/4" aluminum cap on a 3/4" rebar, stamped PE-LS No. 9853-2010. Said bearing is based upon project coordinates.

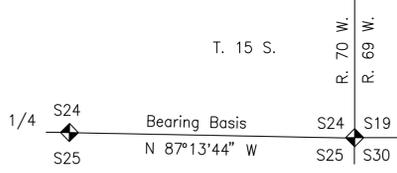

Length Of Project 2357± Feet

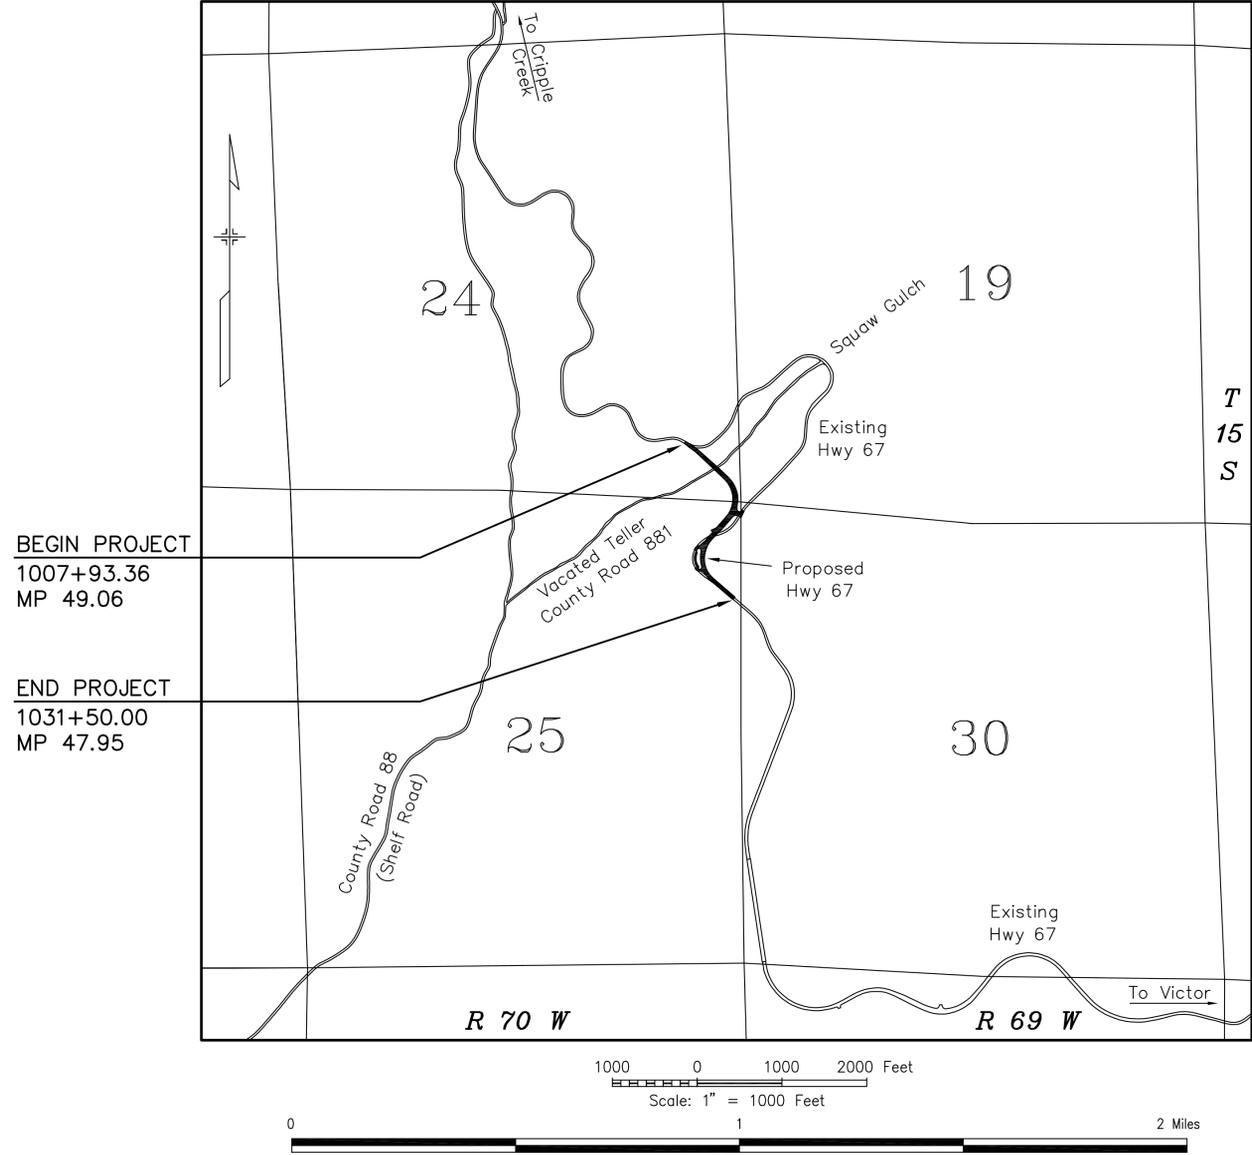

SHEET NO.	INDEX OF SHEETS
1	Title Sheet
2	Tabulation of Properties
3	Survey Control Diagram
4	Monumentation Sheet
5-6	Ownership Map
7-8	Plan Sheets

1. This Right-of-Way Plan is not a land survey plat resulting from a monumented land survey of all adjoining properties and was prepared for the exclusive use of Cripple Creek & Victor Gold Mining Company and the Colorado Department of Transportation.

2. For all information regarding right to title and easements, rights-of-way or other title burdens affecting such right to title to this property, Foresight West Surveying Inc. relied upon title commitments issued by Front Range Title, LLC, with commitment numbers and effective dates listed on the Tabulation of Properties sheet (sheet 2).

SURVEYOR'S CERTIFICATION:

I, John W. Christy, Colorado Professional Land Surveyor No. 17477, hereby certify that this survey was performed under my responsible charge in accordance with applicable standards of practice, and that this Right-of-Way Plan is a correct representation thereof to the best of my knowledge, information and belief. Under Colorado law, this certification does not constitute a guaranty or warranty, either expressed or implied.

Signature and date through seal:
(Required by Colorado law)



FILING CERTIFICATION:

DEPOSITED THIS ___ DAY OF ___, 20___, AT ___M., FOR INFORMATION ONLY IN BOOK ___ OF THE COUNTY LAND SURVEYS/RIGHT OF WAY SURVEYS AT PAGE ___, RECEPTION NUMBER ___.

SIGNED _____
DEPT. _____

Print Date: Nov 19, 2012, 10:35:45am	Sheet Revisions			Cripple Creek & Victor Gold Mining Company		As Constructed		Contract Information		Project No./Code	
File Name: SH-67 Realignment.dwg	Date:	Comments	Init.	Cripple Creek & Victor Gold Mining Company 100 North 3rd Street, Victor, CO 80860 Phone: 719-689-4242 FAX: 719-689-9194		No Revisions:	Contractor:		STA 067A-032		
Horiz. Scale: As Shown Units: U.S. Survey Foot						Revised:	Resident Engineer:		19316		
Foresight West Surveying Inc. 2755 S. Locust St Suite 120 Denver, CO 80222 303-504-4440						Void:	PROJECT STARTED: / / ACCEPTED: / /		Sheet Number 1		