


PadillaK 3:27:59 PM pw:\ABOPWINT01.wilsonco.com\Wilson_Projects\Documents\8100-TRN\CDDT\13-100-312-01_125-Cimarron_Interch\19039\Utilities\Drawings\Exhibit Drawings\Utility Pothole Site Plan

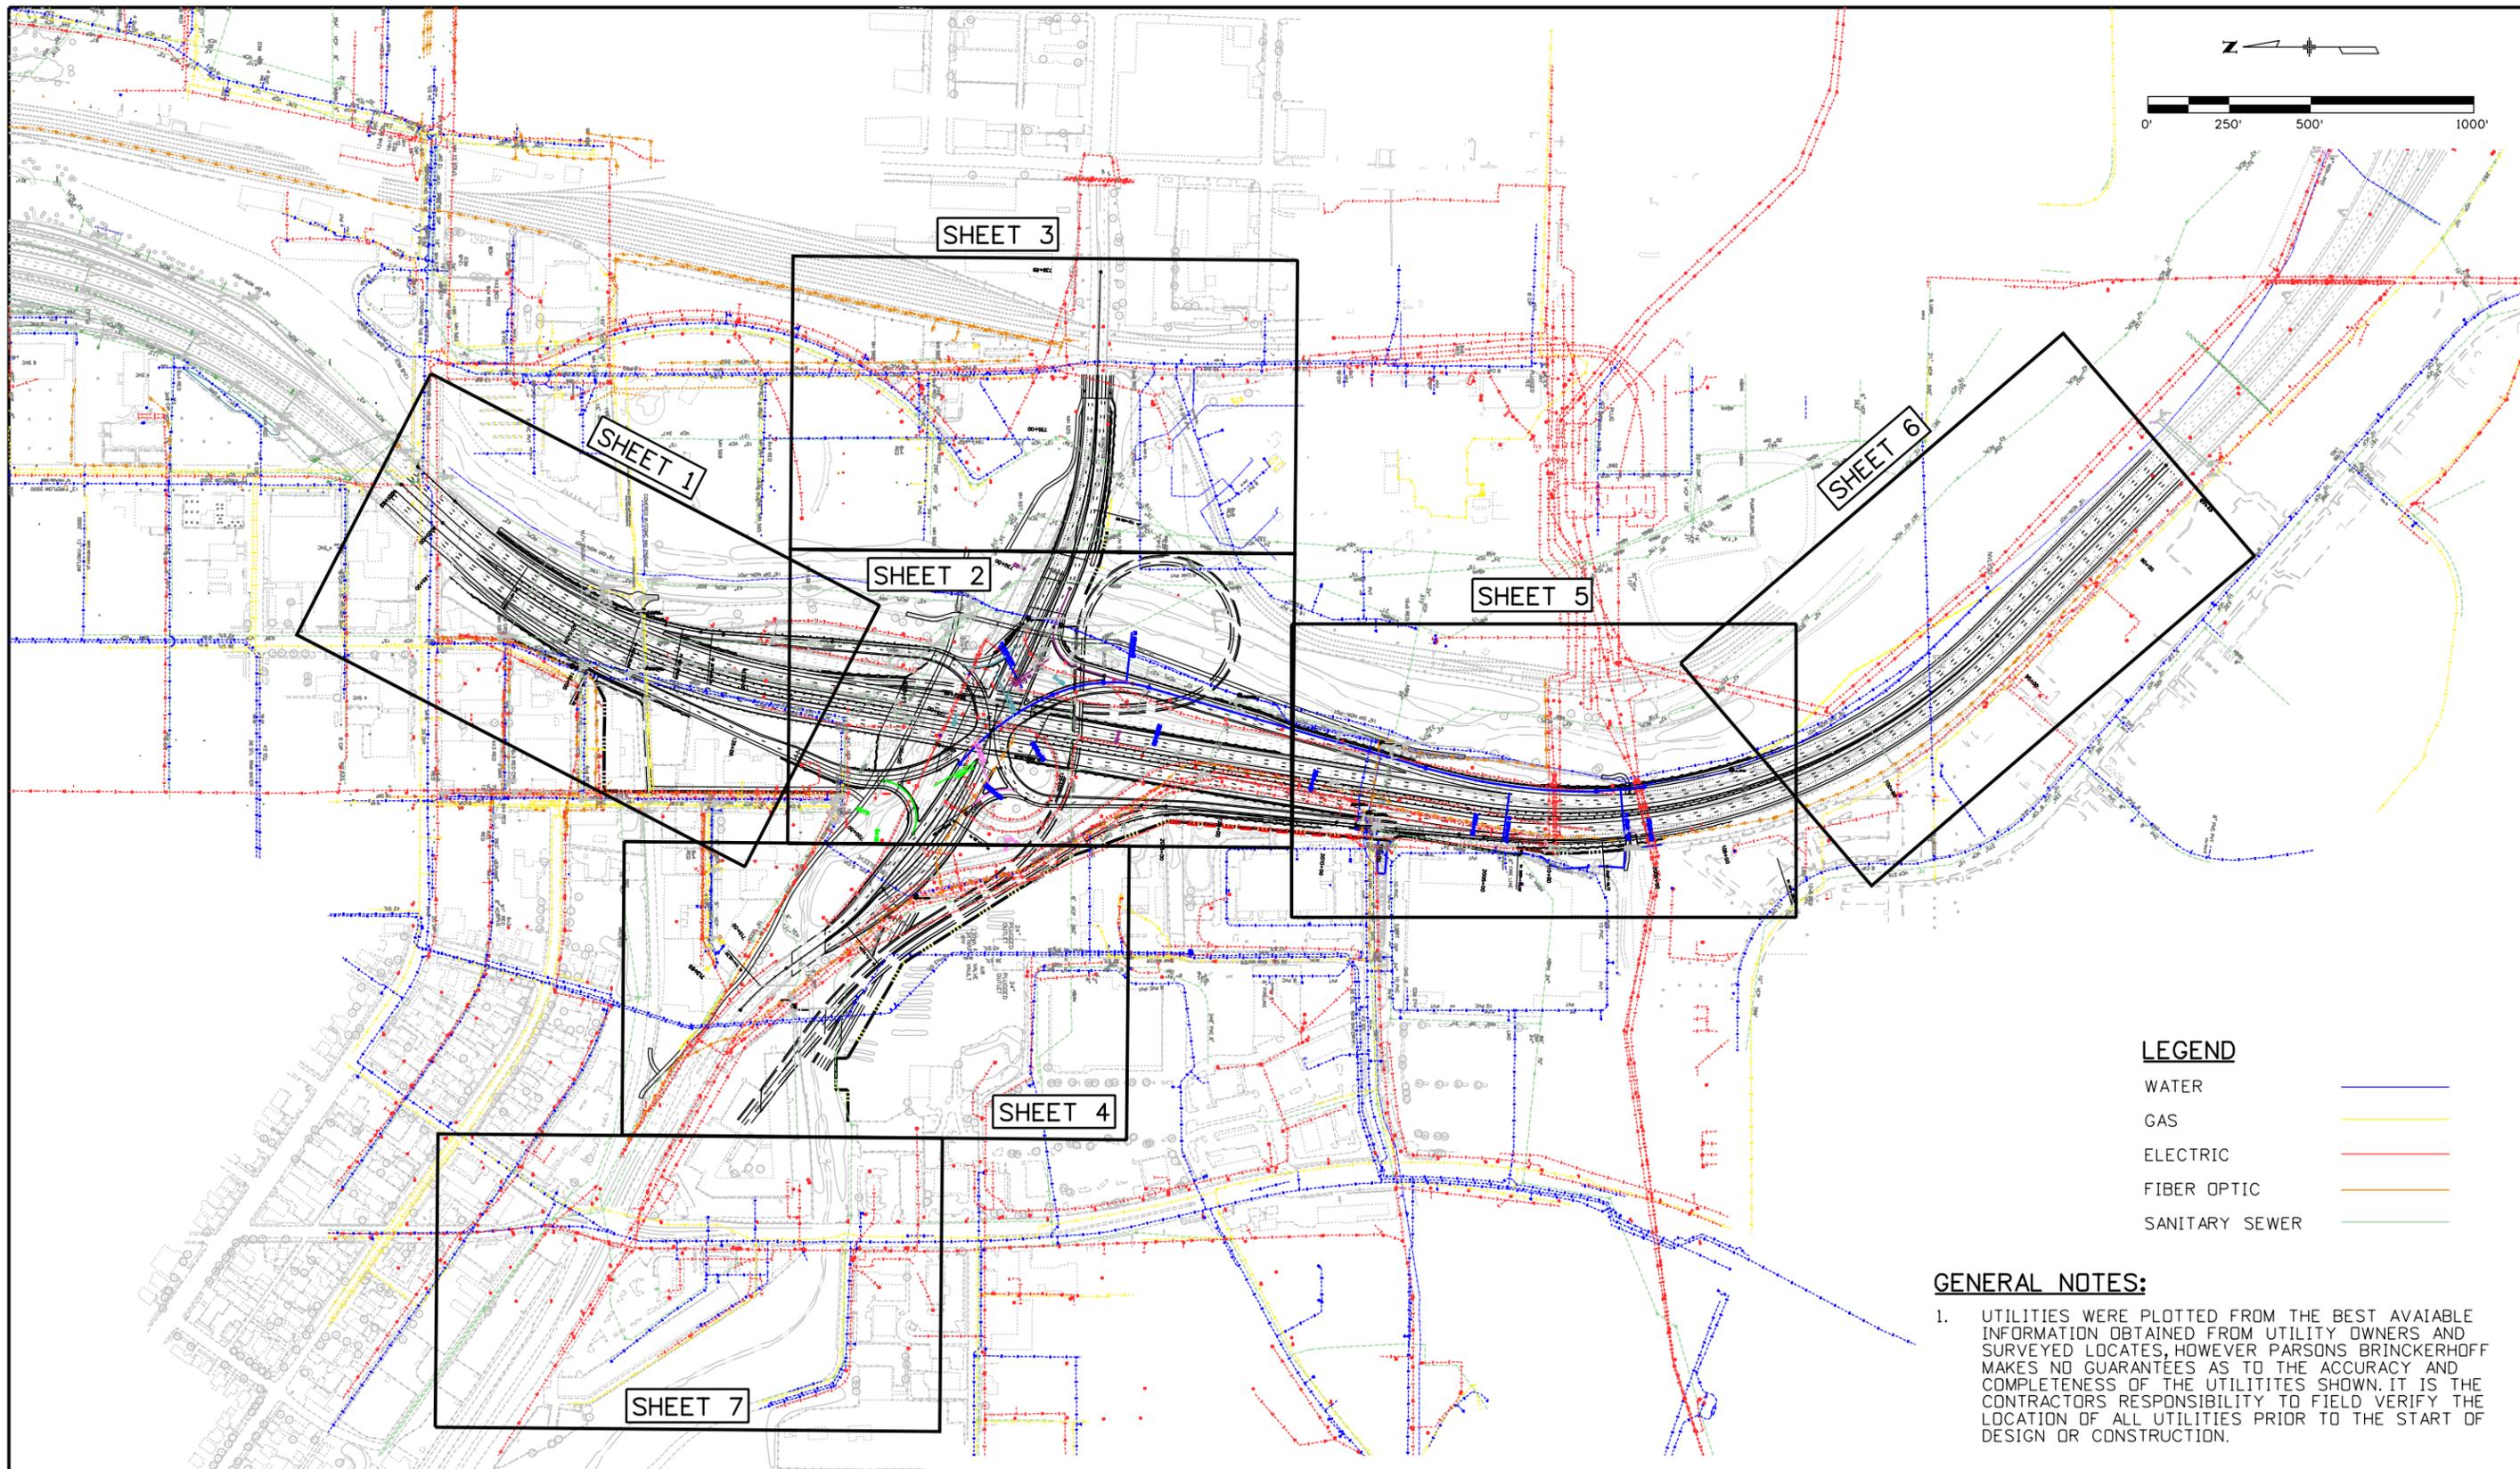


Print Date: 5/27/2014		Sheet Revisions			Colorado Department of Transportation		As Constructed		UTILITY POTHOLES SITE PLAN		Project No./Code	
File Name: Utility Pothole Site Plan		Date:	Comments	Init.	 1480 Quail Lake Loop, Suite A Colorado Springs, CO 80906 Phone: 719-634-2323 FAX: 719-227-3298 Region 2 DMW		No Revisions:		Designer: XXXXXXXX		IM 0252-423	
Horiz. Scale: 1:500 Vert. Scale:							Revised:		Detailer: XXXXXXXX		19039	
Unit Information Unit Leader Initials							Void:		Subset: _SG		Subset Sheets: _SN of _SO	
555 17th Street Suite 500 Denver, CO 80202												

Padlak 10:40:58 AM p:\w\ABQP\W\T01.wilson\Projects\Documents\8100-TRN\CDOT\13-100-312-01\125_Cimarron_Interch\Drawings\Utilities\Drawings\Exhibit Drawings\Pothole_Sheet 1

POTHOLE INFORMATION

	TOP ELEV	BOTTOM ELEV
PH #1	5961.3'	5961.1'
PH #2	5963.4'	5962.4'
PH #3	5964.3'	5963.3'

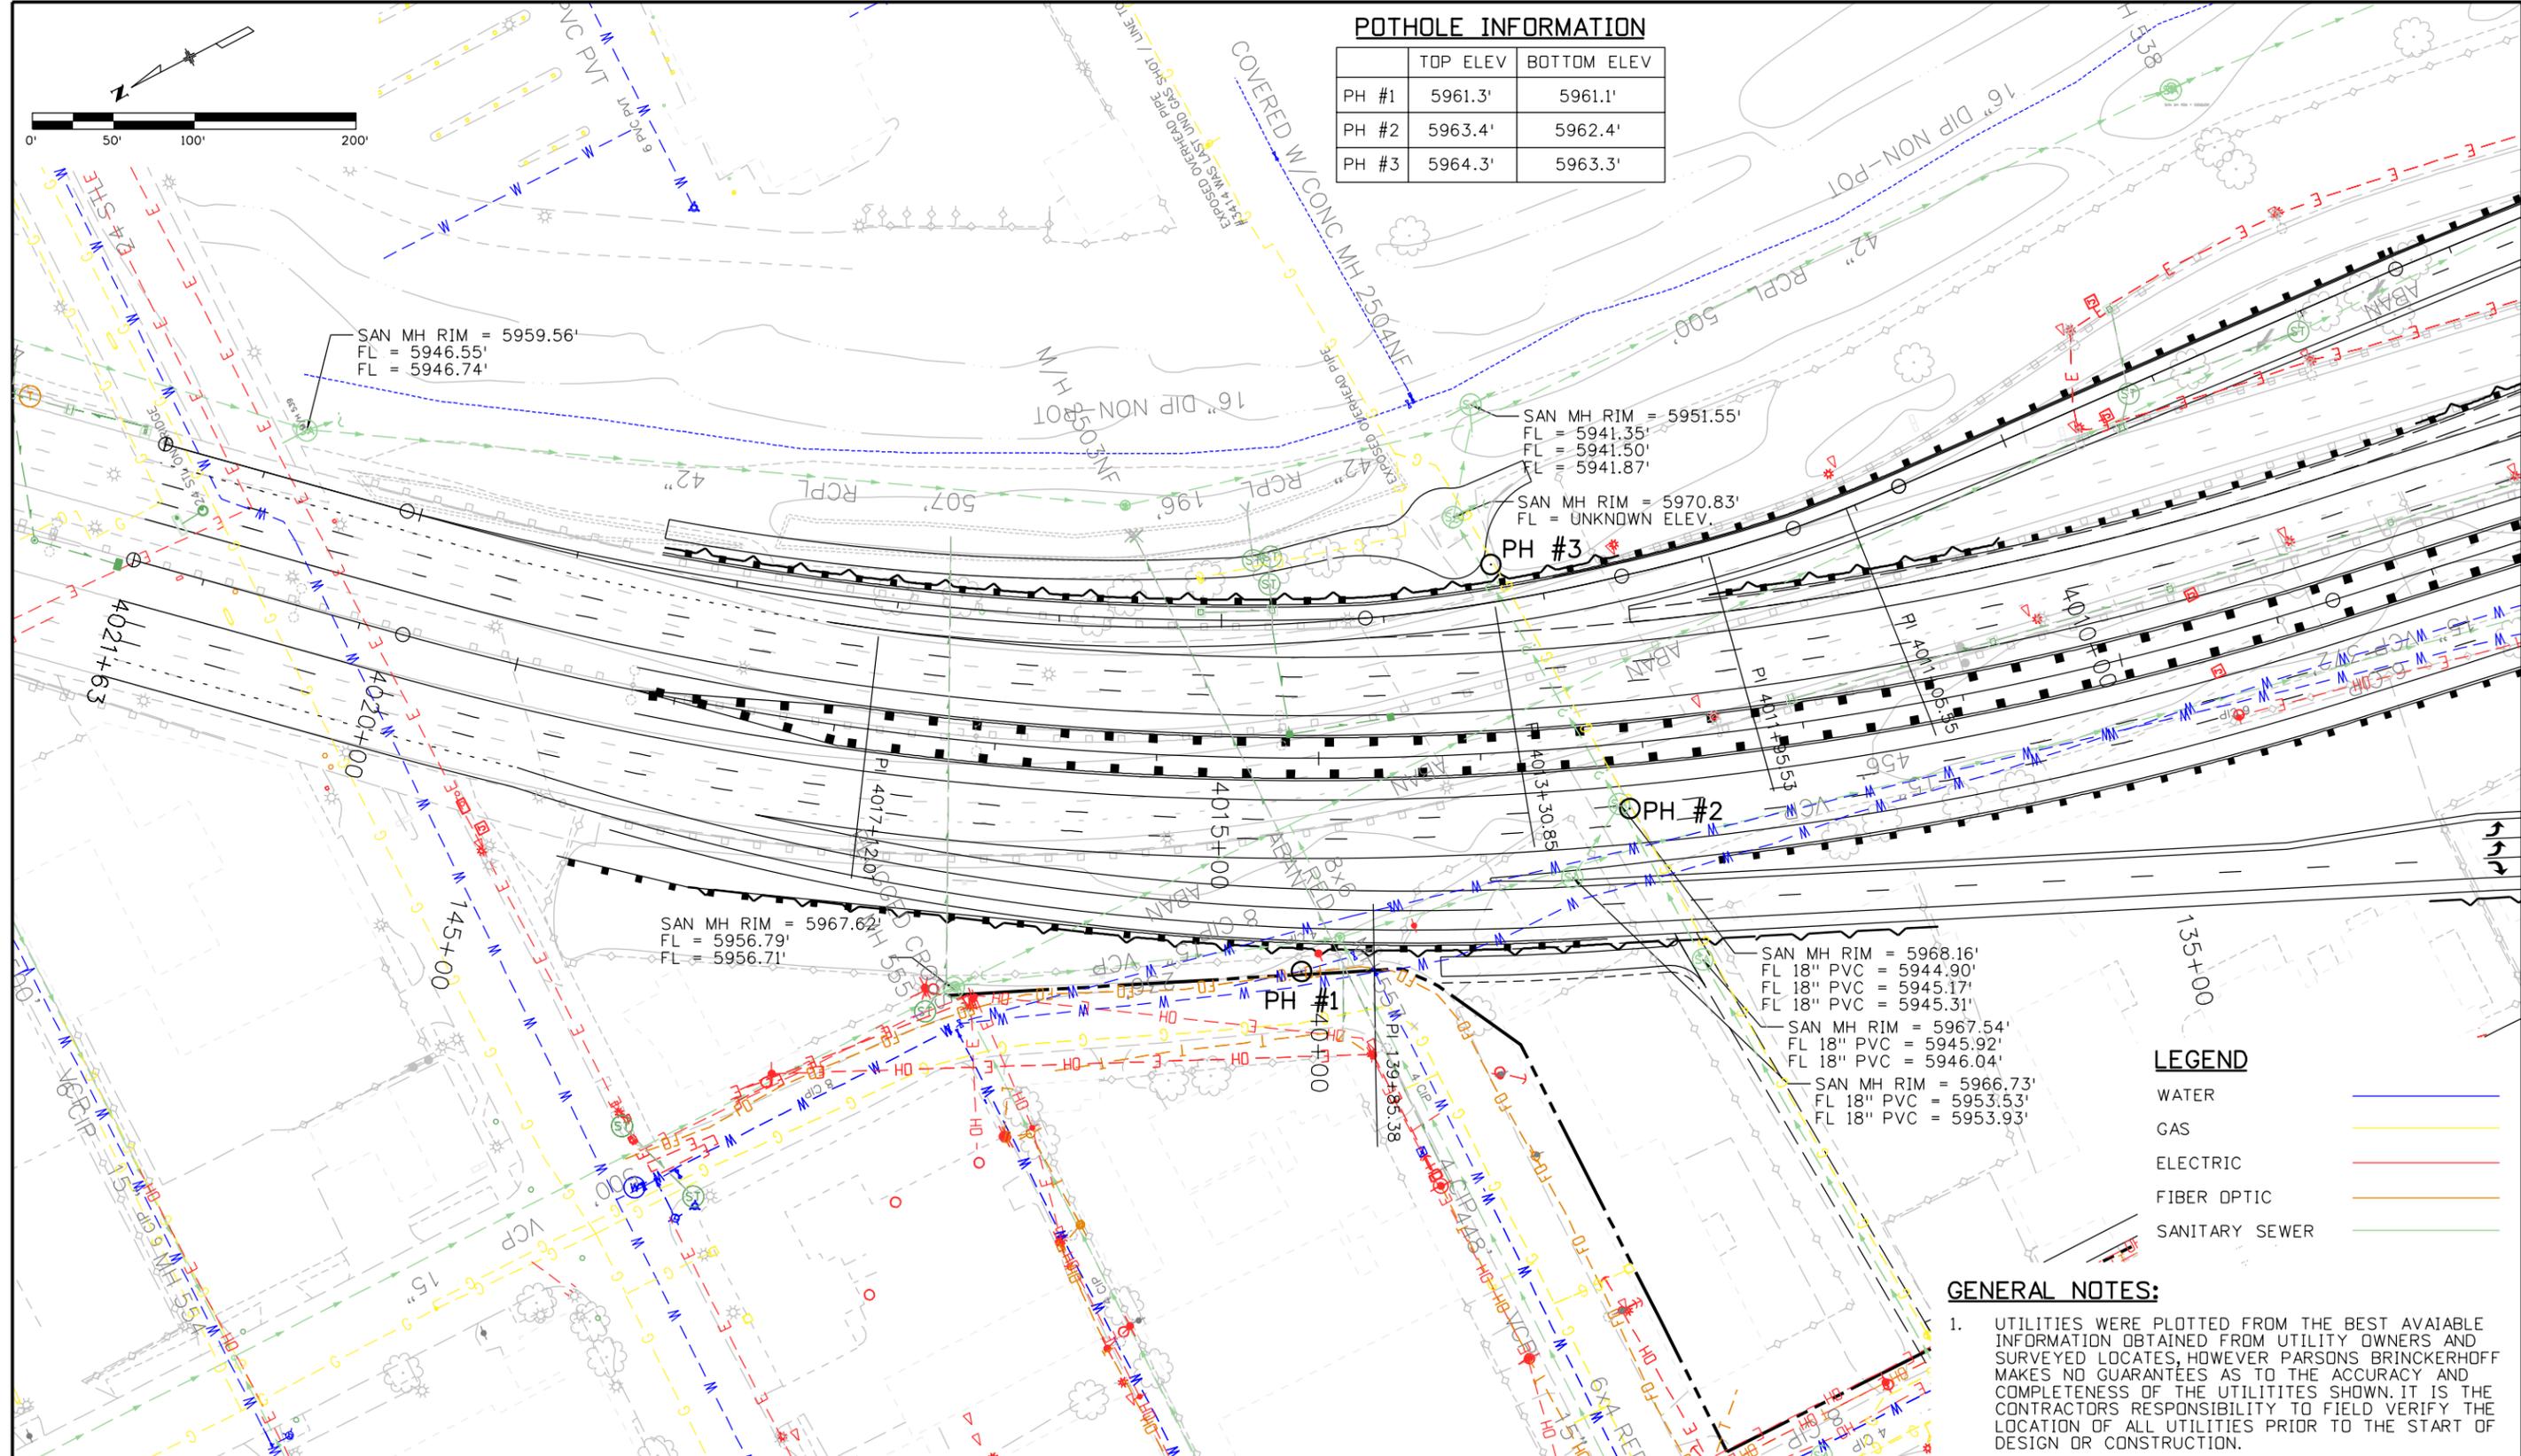

LEGEND

WATER	
GAS	
ELECTRIC	
FIBER OPTIC	
SANITARY SEWER	

GENERAL NOTES:

- UTILITIES WERE PLOTTED FROM THE BEST AVAILABLE INFORMATION OBTAINED FROM UTILITY OWNERS AND SURVEYED LOCATES, HOWEVER PARSONS BRINCKERHOFF MAKES NO GUARANTEES AS TO THE ACCURACY AND COMPLETENESS OF THE UTILITIES SHOWN. IT IS THE CONTRACTORS RESPONSIBILITY TO FIELD VERIFY THE LOCATION OF ALL UTILITIES PRIOR TO THE START OF DESIGN OR CONSTRUCTION.

Print Date: 5/28/2014	
File Name: Pothole Sheet 1	
Horiz. Scale: 1:100	Vert. Scale:
Unit Information	Unit Leader Initials
	555 17th Street Suite 500 Denver, CO 80202

Sheet Revisions		
Date:	Comments	Init.

Colorado Department of Transportation


 1480 Quail Lake Loop, Suite A
 Colorado Springs, CO 80906
 Phone: 719-634-2323 FAX: 719-227-3298
Region 2 **DMW**

As Constructed
No Revisions:
Revised:
Void:

UTILITY POTHOLES MAP SHEET 1 OF 7			
Designer:	XXXXXXXX	Structure	
Detailer:	XXXXXXXX	Numbers	
Subset:	_SG	Subset Sheets:	_SN of _SO

Project No./Code
IM 0252-423
19039
Sheet Number _ON

Padlak 3:10:44 PM p:\ABOPWINTOI.wilsonco.com\Wilson_Proj\19039\DOT\13-100-312-01_125_Cimarron_Interch\19039\Utilities\Drawings\Exhibit Drawings\Pothole Sheet 3

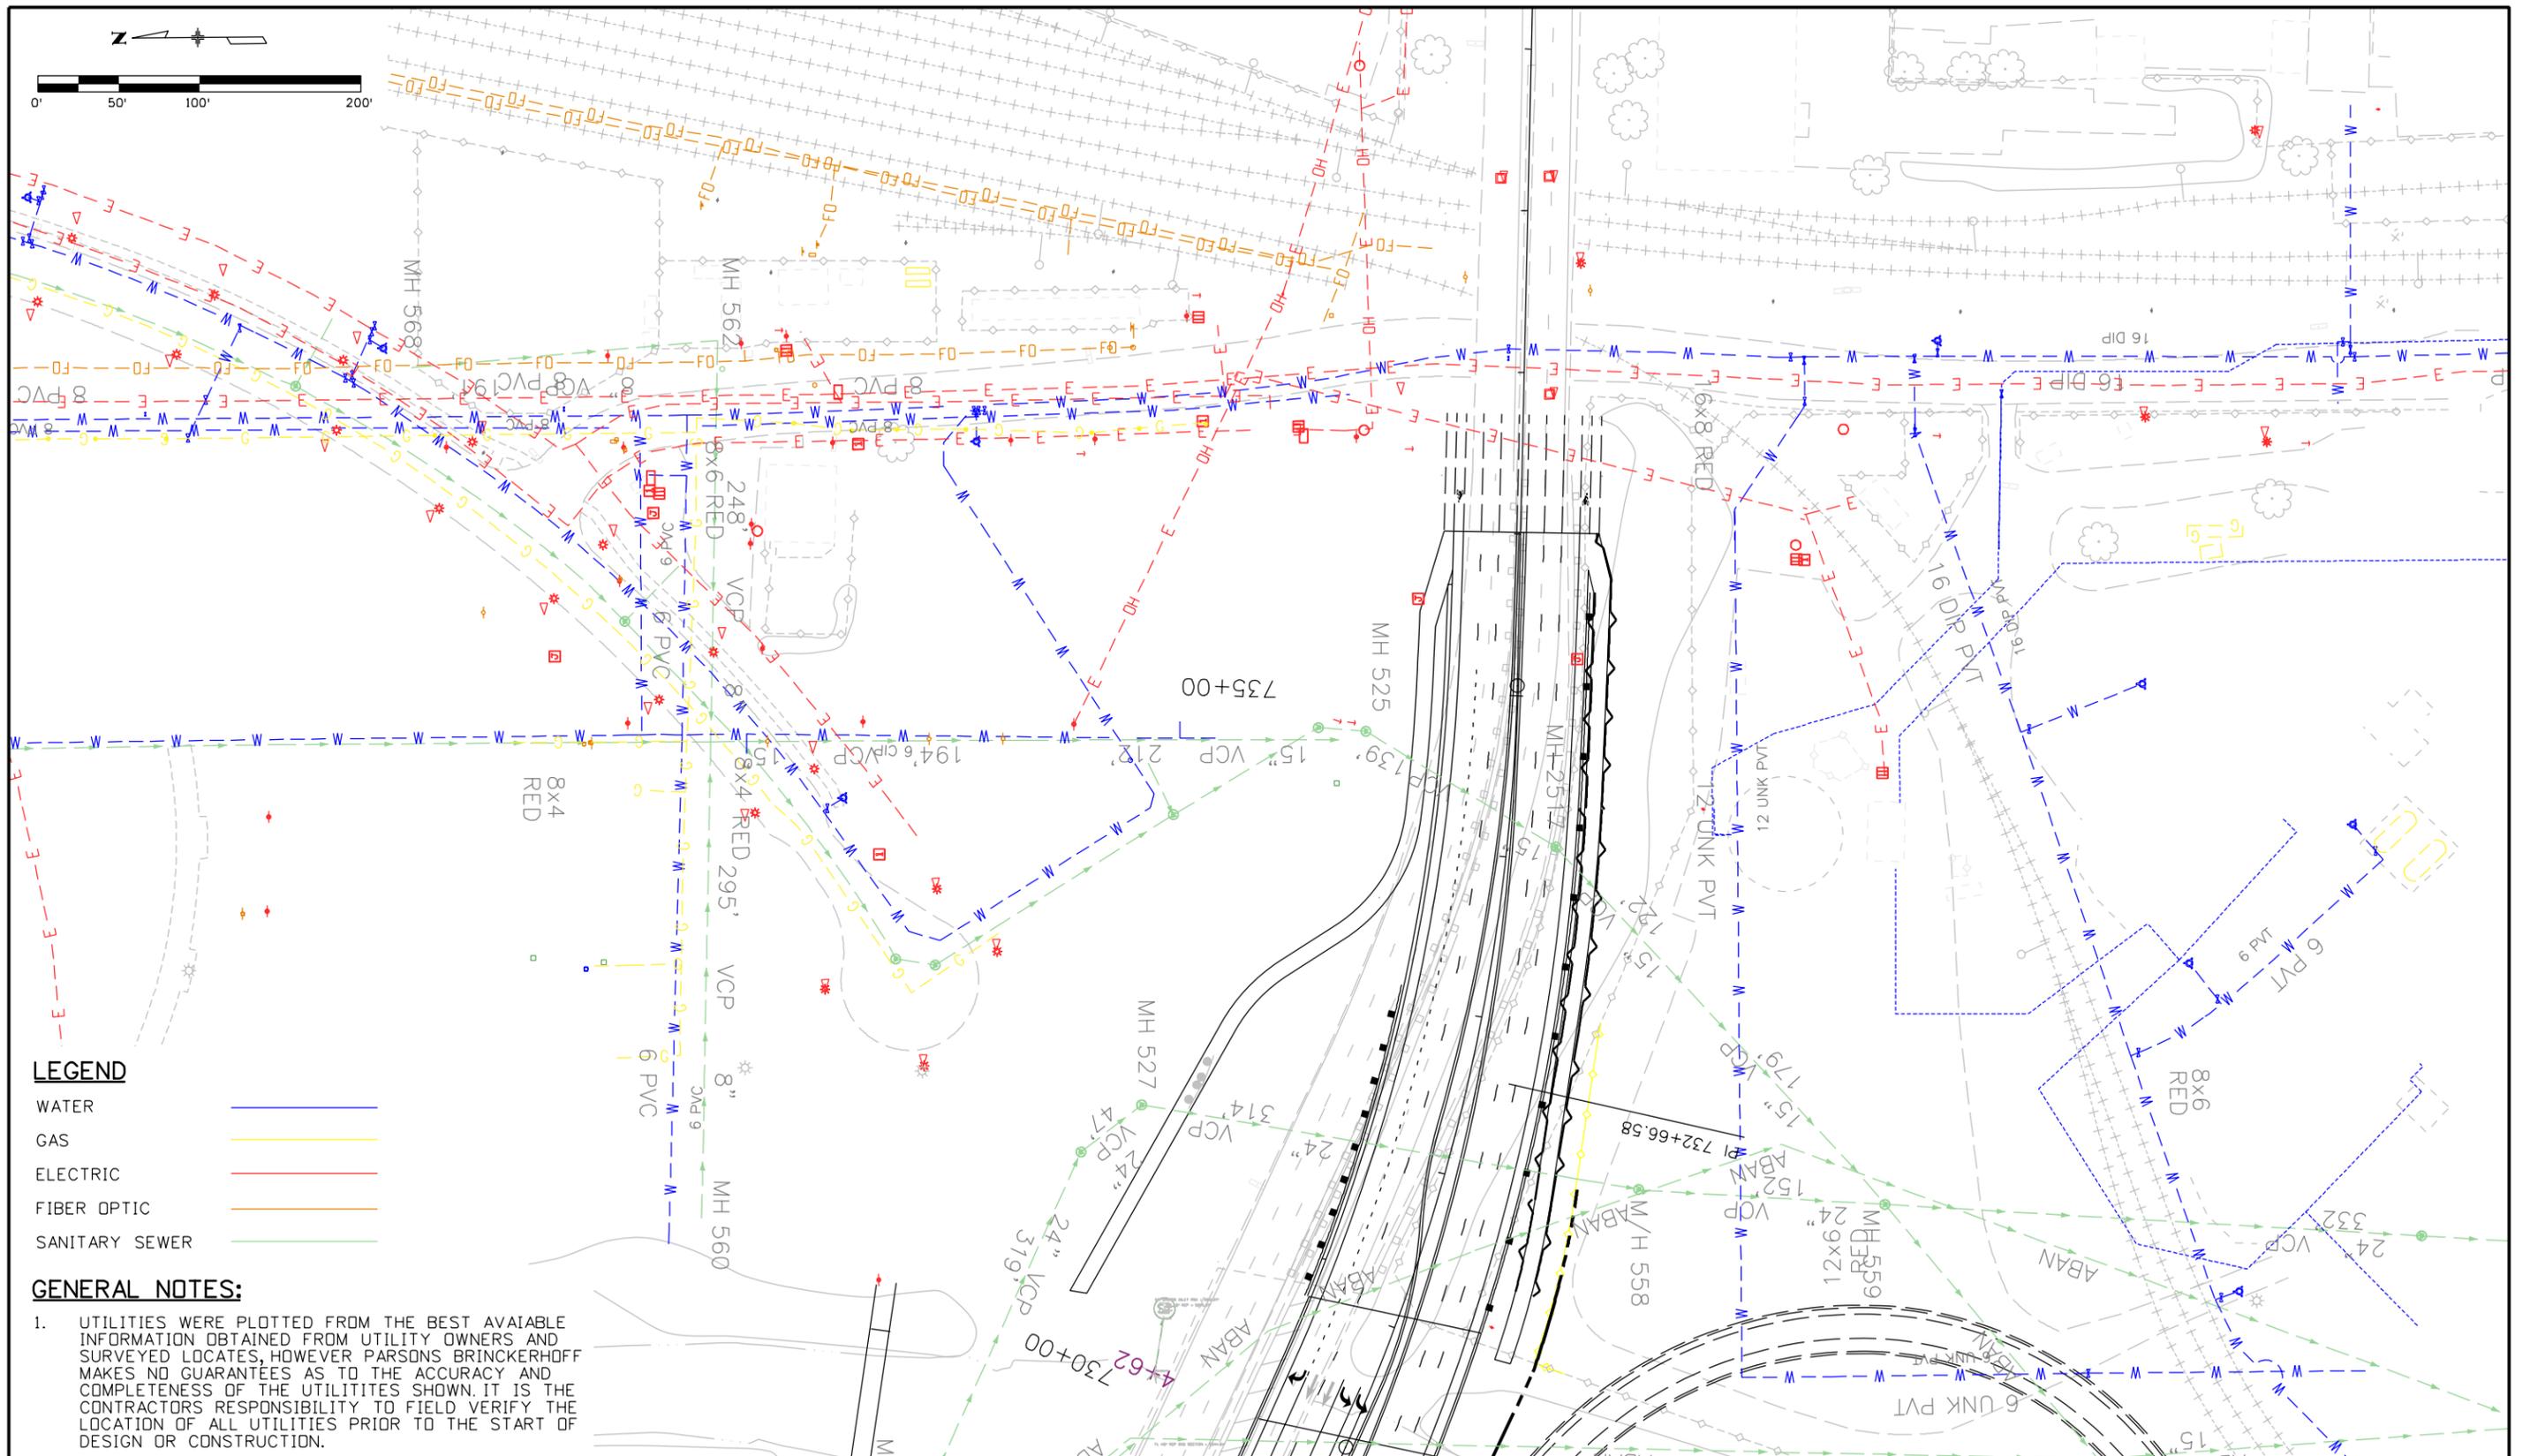

Print Date: 5/27/2014	
File Name: Pothole Sheet 3	
Horiz. Scale: 1:100	Vert. Scale:
Unit Information	Unit Leader Initials
	555 17th Street Suite 500 Denver, CO 80202

Sheet Revisions		
Date:	Comments	Init.

Colorado Department of Transportation


 1480 Quail Lake Loop, Suite A
 Colorado Springs, CO 80906
 Phone: 719-634-2323 FAX: 719-227-3298
Region 2 **DMW**

As Constructed
No Revisions:
Revised:
Void:

UTILITY POTHOLES MAP			
SHEET 3 OF 7			
Designer:	XXXXXXXX	Structure	
Detailer:	XXXXXXXX	Numbers	
Subset:	_SG	Subset Sheets:	_SN of _SO

Project No./Code
IM 0252-423
19039
Sheet Number _ON

Padlak 11:04:40 AM p:\ABOPWINT01.wilsonco.com\Projects\Documents\8100-TRN\CDOT\13-100-312-01_125-Cimarron_Interch\19039_Uilities\Drawings\Exhibit Drawings\Pothole Sheet 4

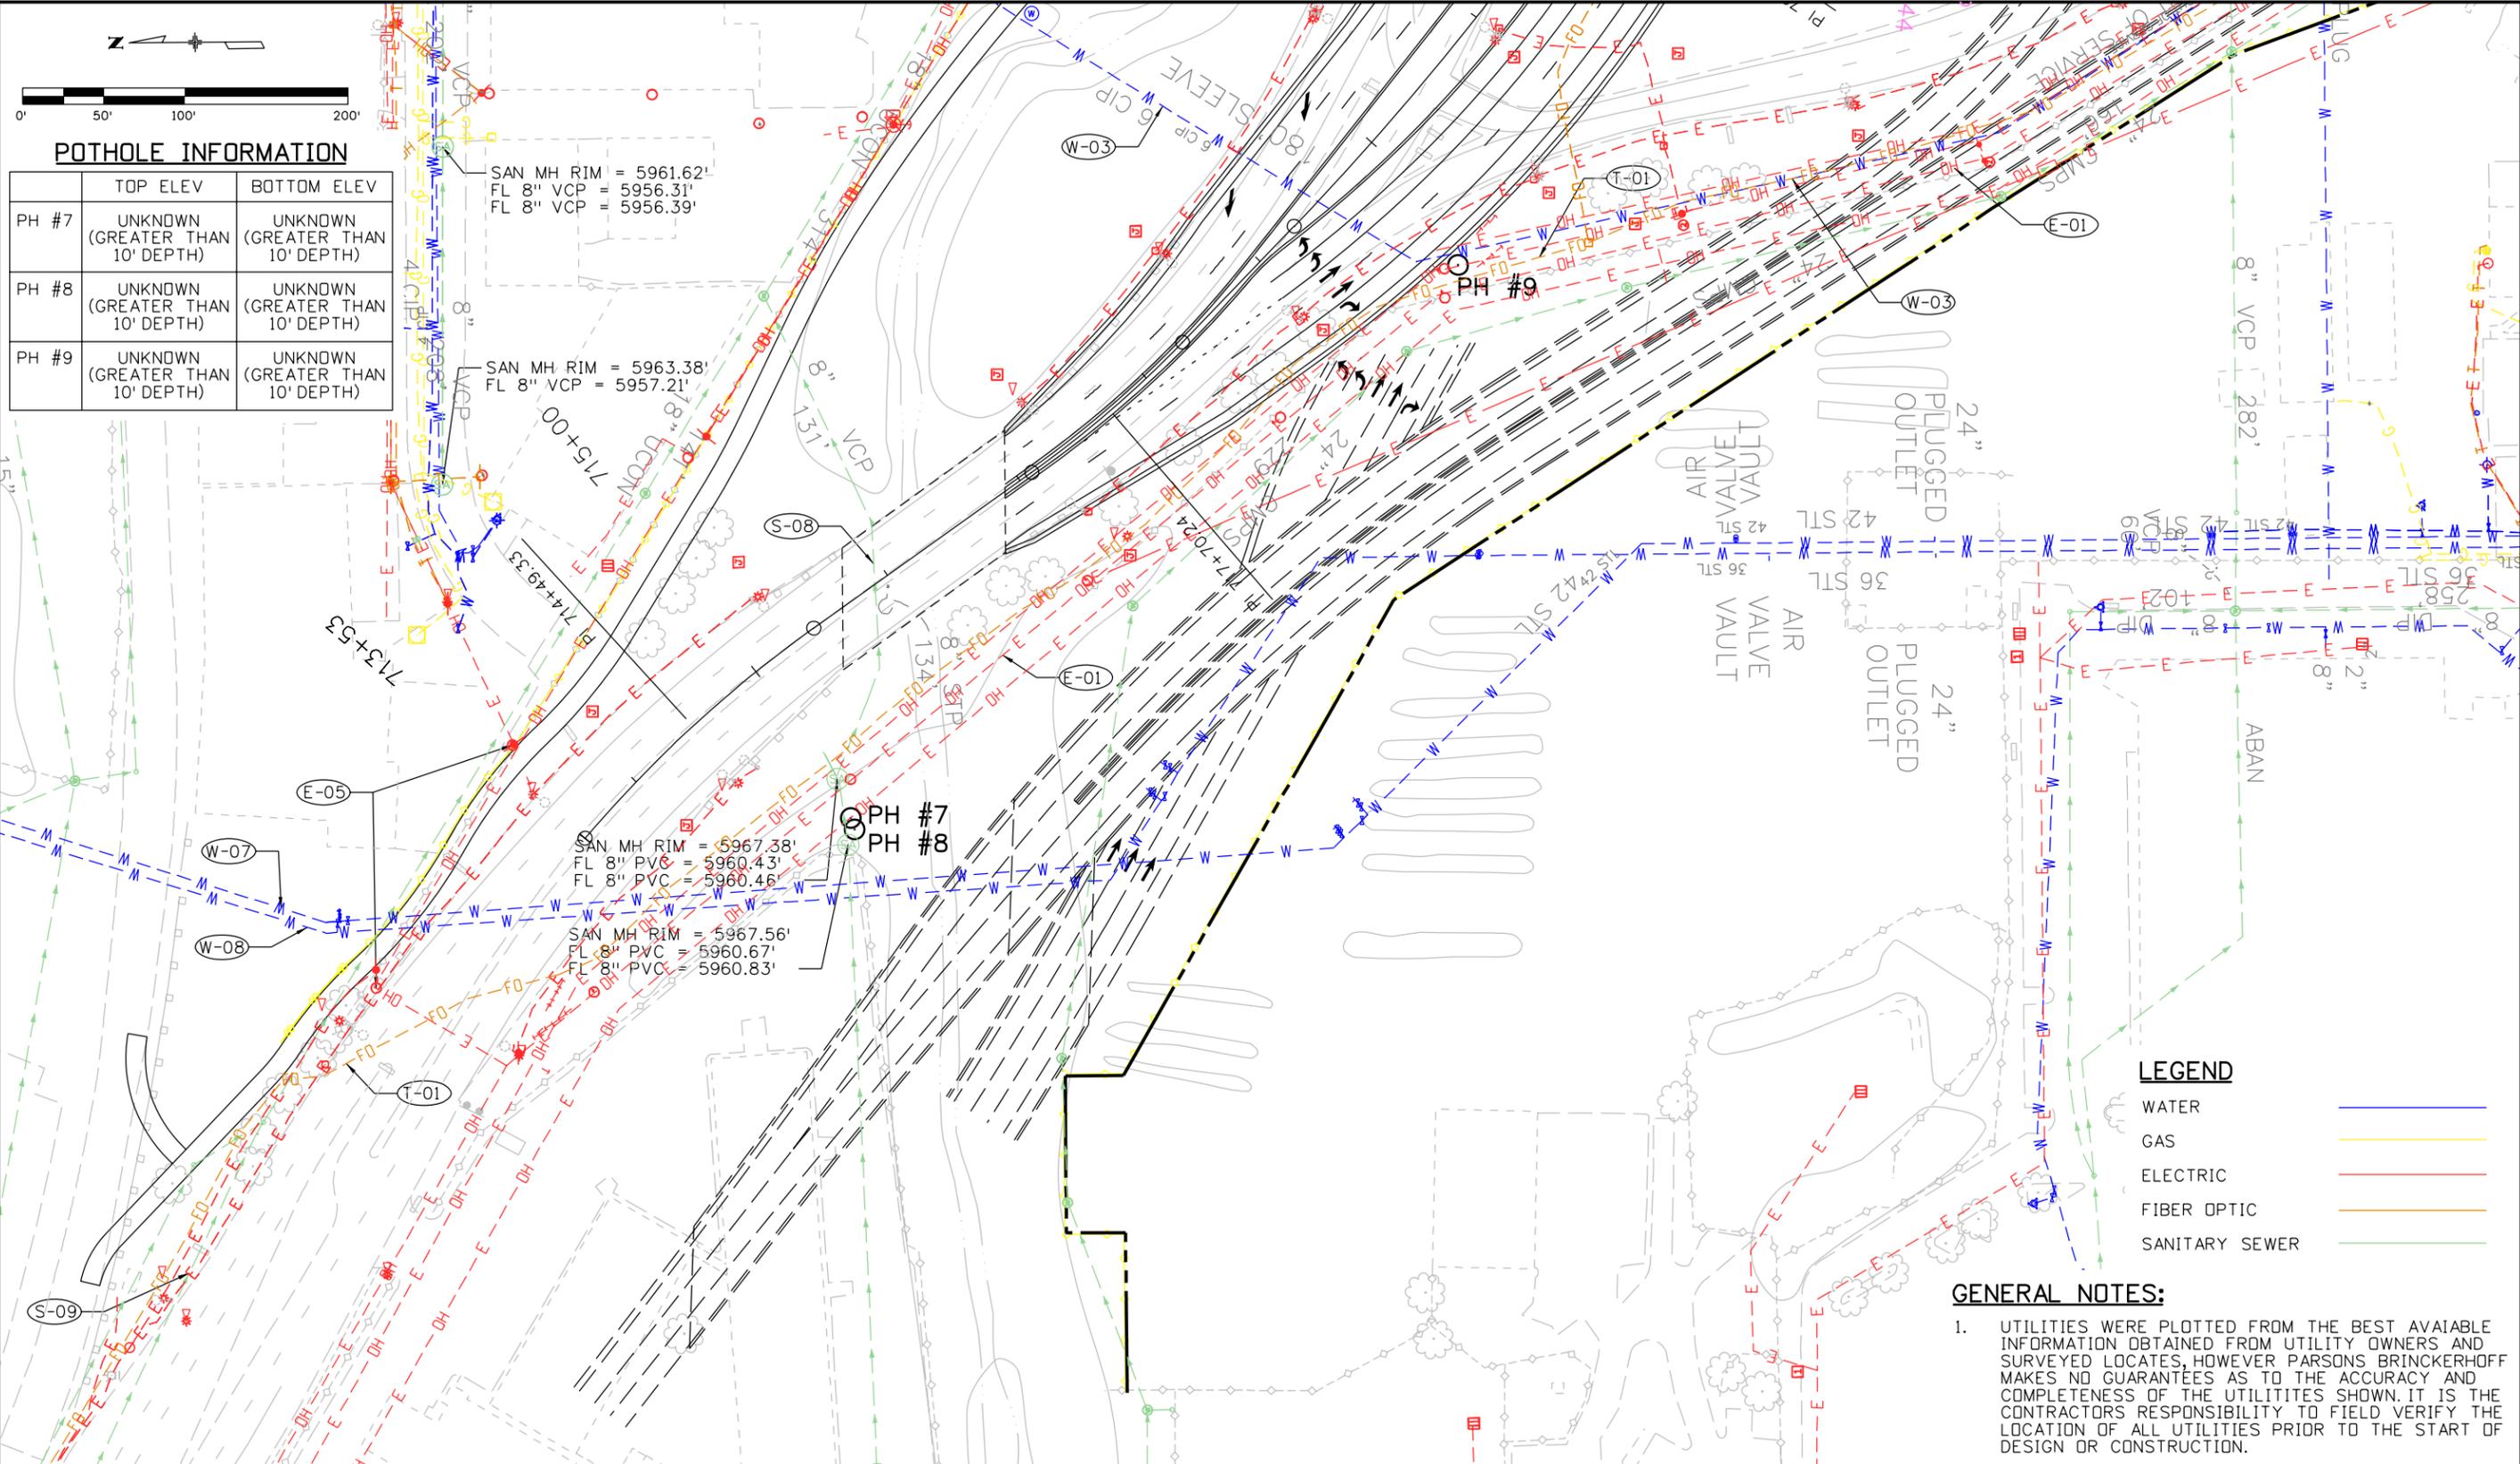

POTHOLE INFORMATION

PH #	TOP ELEV	BOTTOM ELEV
PH #7	UNKNOWN (GREATER THAN 10' DEPTH)	UNKNOWN (GREATER THAN 10' DEPTH)
PH #8	UNKNOWN (GREATER THAN 10' DEPTH)	UNKNOWN (GREATER THAN 10' DEPTH)
PH #9	UNKNOWN (GREATER THAN 10' DEPTH)	UNKNOWN (GREATER THAN 10' DEPTH)

SAN MH RIM = 5961.62'
 FL 8" VCP = 5956.31'
 FL 8" VCP = 5956.39'

SAN MH RIM = 5963.38'
 FL 8" VCP = 5957.21'

SAN MH RIM = 5967.38'
 FL 8" PVC = 5960.43'
 FL 8" PVC = 5960.46'

SAN MH RIM = 5967.56'
 FL 8" PVC = 5960.67'
 FL 8" PVC = 5960.83'

LEGEND

WATER	
GAS	
ELECTRIC	
FIBER OPTIC	
SANITARY SEWER	

GENERAL NOTES:

- UTILITIES WERE PLOTTED FROM THE BEST AVAILABLE INFORMATION OBTAINED FROM UTILITY OWNERS AND SURVEYED LOCATES, HOWEVER PARSONS BRINCKERHOFF MAKES NO GUARANTEES AS TO THE ACCURACY AND COMPLETENESS OF THE UTILITIES SHOWN. IT IS THE CONTRACTORS RESPONSIBILITY TO FIELD VERIFY THE LOCATION OF ALL UTILITIES PRIOR TO THE START OF DESIGN OR CONSTRUCTION.

Print Date: 5/28/2014
File Name: Pothole Sheet 4
Horiz. Scale: 1:100 Vert. Scale:
Unit Information Unit Leader Initials
555 17th Street
Suite 500
Denver, CO 80202

Sheet Revisions		
Date:	Comments	Init.

Colorado Department of Transportation



 1480 Quail Lake Loop, Suite A
 Colorado Springs, CO 80906
 Phone: 719-634-2323 FAX: 719-227-3298
Region 2 **DMW**

As Constructed
No Revisions:
Revised:
Void:

UTILITY POTHOLES MAP SHEET 4 OF 7			
Designer: XXXXXXXX	Structure Numbers		
Detailer: XXXXXXXX	Subset Sheets: _SN of _SO		
Subset: _SG			

Project No./Code
IM 0252-423
19039
Sheet Number _ON

Padlak 11:29:46 AM p:\ABQPWINT01.wilsonco.com\Projects\Documents\8100-TRN\CDOT\13-100-312-01_125-Cimarron_Interch\Utilities\Drawings\Exhibit Drawings\Pothole Sheet 6

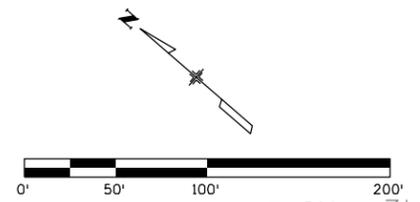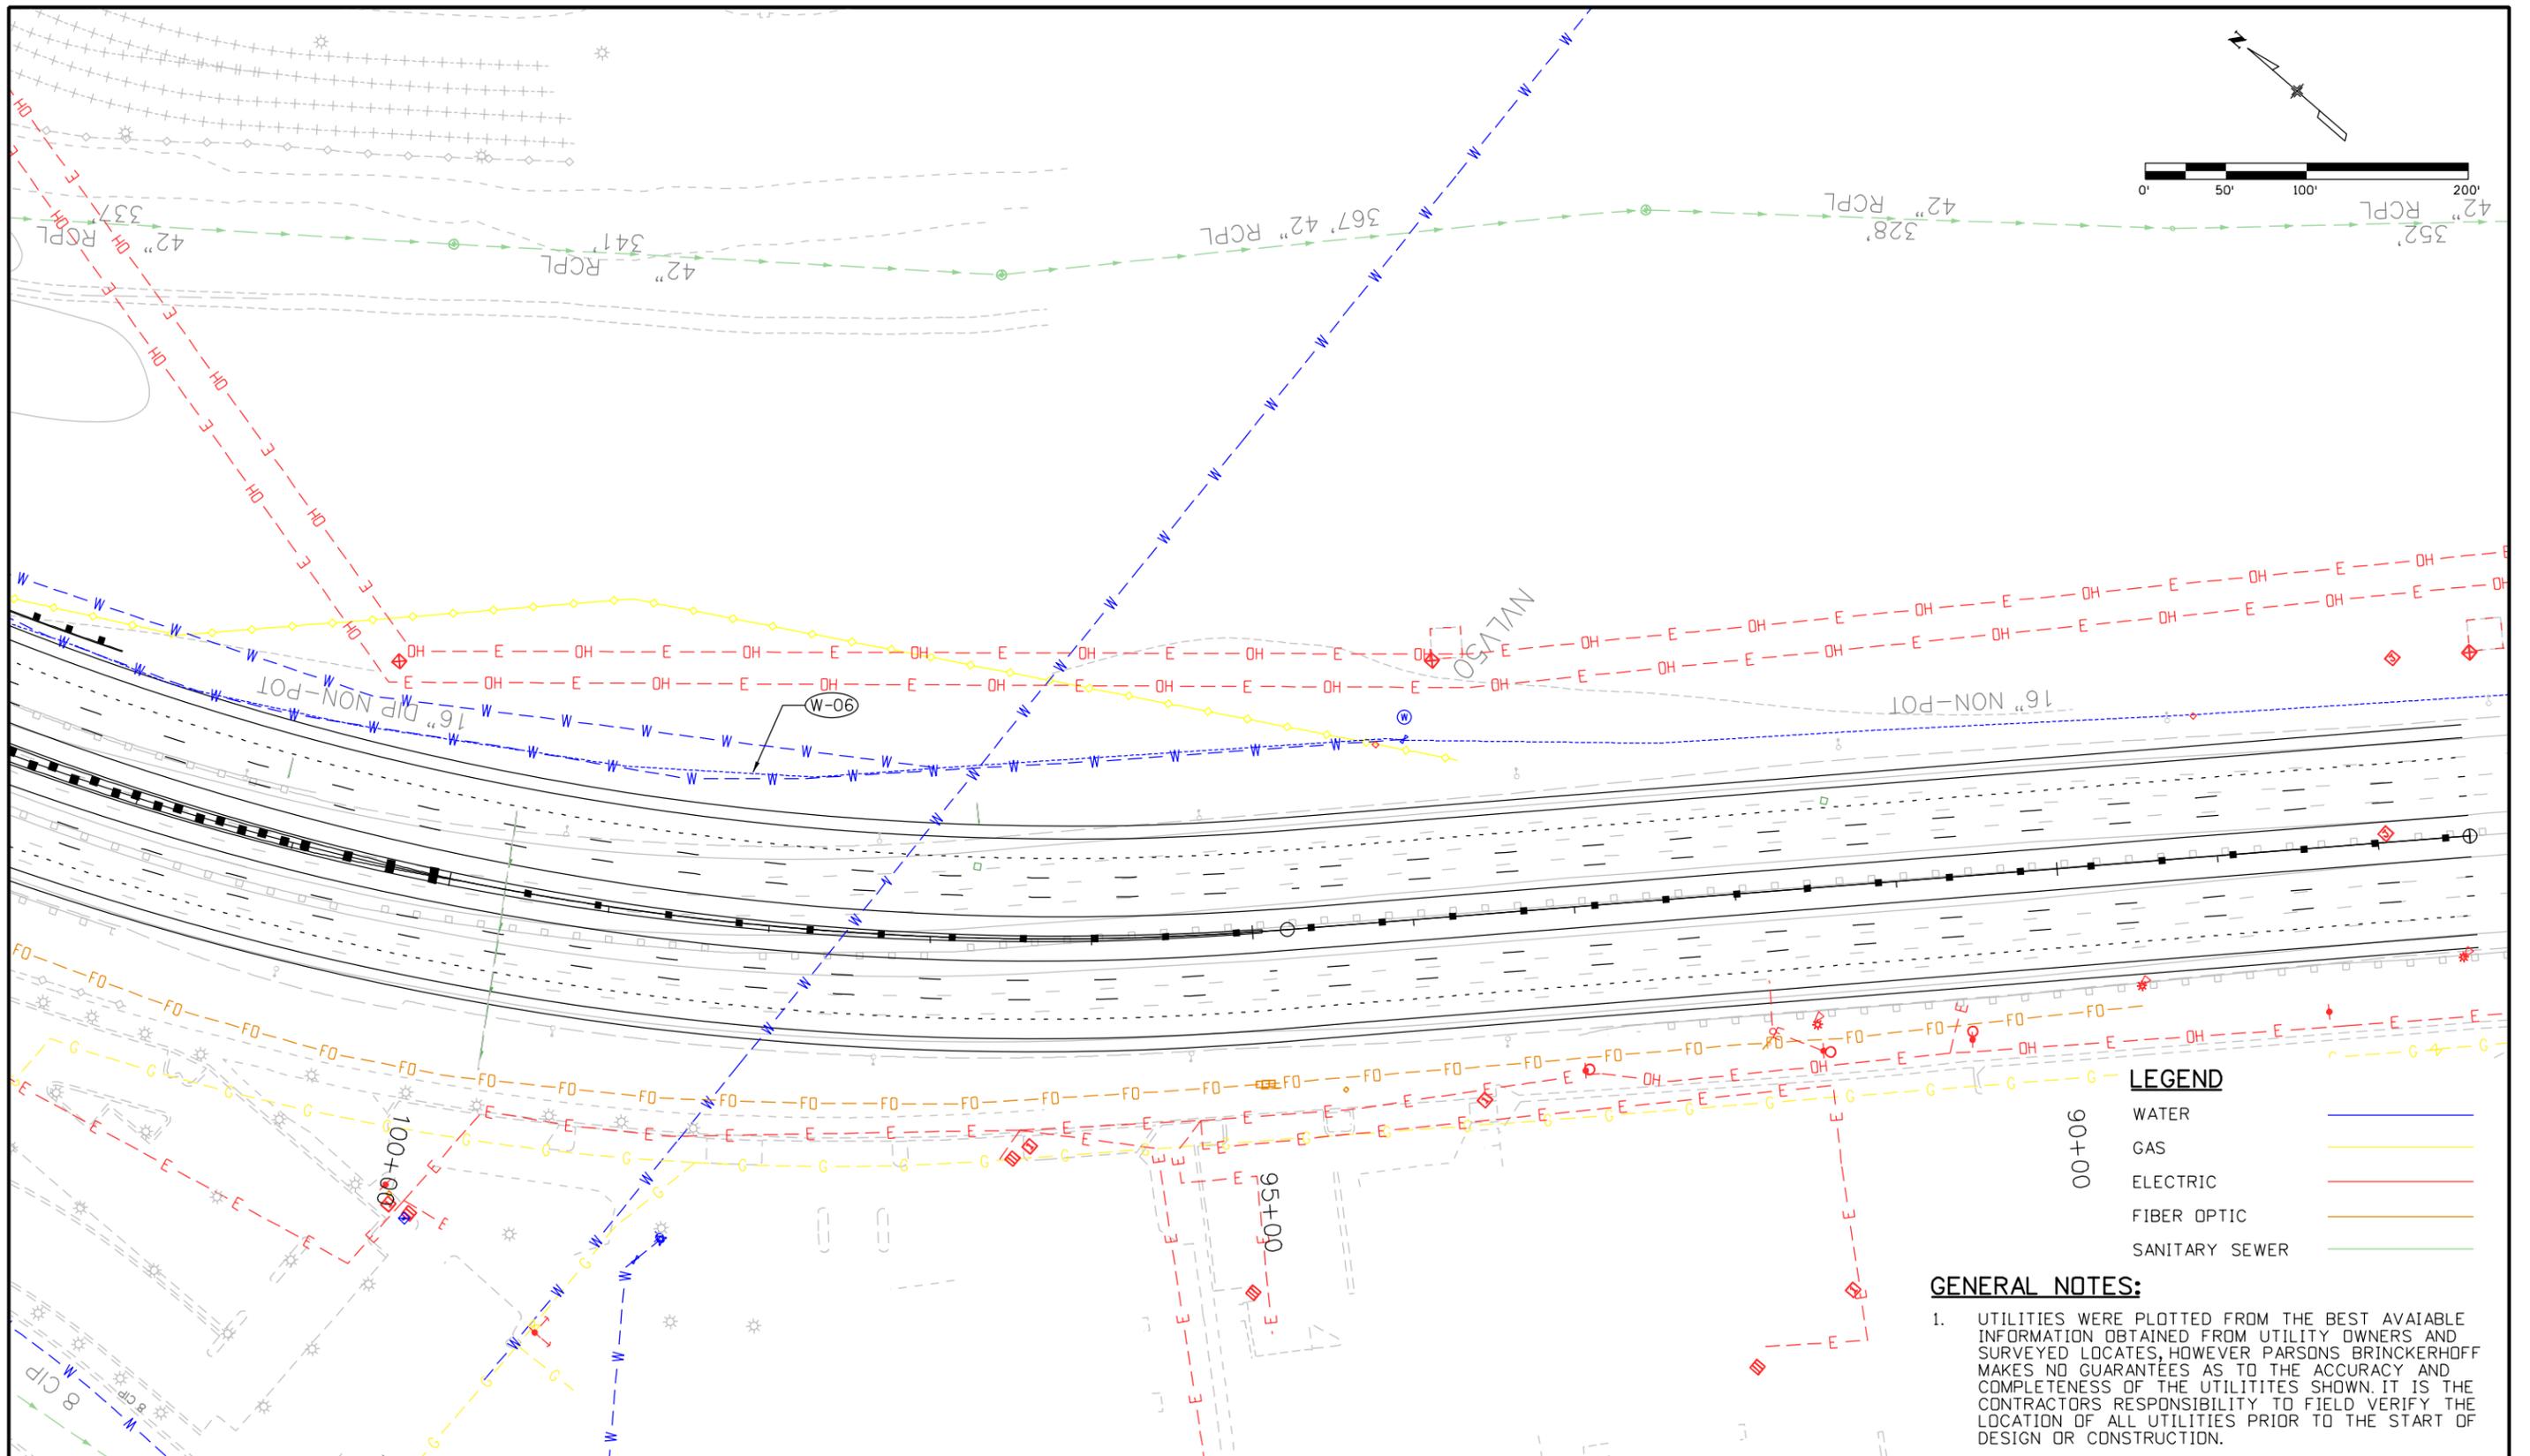

LEGEND	
90+00	WATER
00+00	GAS
	ELECTRIC
	FIBER OPTIC
	SANITARY SEWER

GENERAL NOTES:

- UTILITIES WERE PLOTTED FROM THE BEST AVAILABLE INFORMATION OBTAINED FROM UTILITY OWNERS AND SURVEYED LOCATES, HOWEVER PARSONS BRINCKERHOFF MAKES NO GUARANTEES AS TO THE ACCURACY AND COMPLETENESS OF THE UTILITIES SHOWN. IT IS THE CONTRACTORS RESPONSIBILITY TO FIELD VERIFY THE LOCATION OF ALL UTILITIES PRIOR TO THE START OF DESIGN OR CONSTRUCTION.

Print Date: 5/28/2014	
File Name: Pothole Sheet 6	
Horiz. Scale: 1:100	Vert. Scale:
Unit Information	Unit Leader Initials
555 17th Street	
Suite 500	
Denver, CO 80202	

Sheet Revisions		
Date:	Comments	Init.



Colorado Department of Transportation

 1480 Quail Lake Loop, Suite A
 Colorado Springs, CO 80906
 Phone: 719-634-2323 FAX: 719-227-3298
Region 2 **DMW**

As Constructed
No Revisions:
Revised:
Void:

UTILITY POTHOLES MAP SHEET 6 OF 7			
Designer:	XXXXXXXX	Structure	
Detailer:	XXXXXXXX	Numbers	
Subset:	_SG	Subset Sheets:	_SN of _SD

 Project No./Code
IM 0252-423
19039
Sheet Number _ON

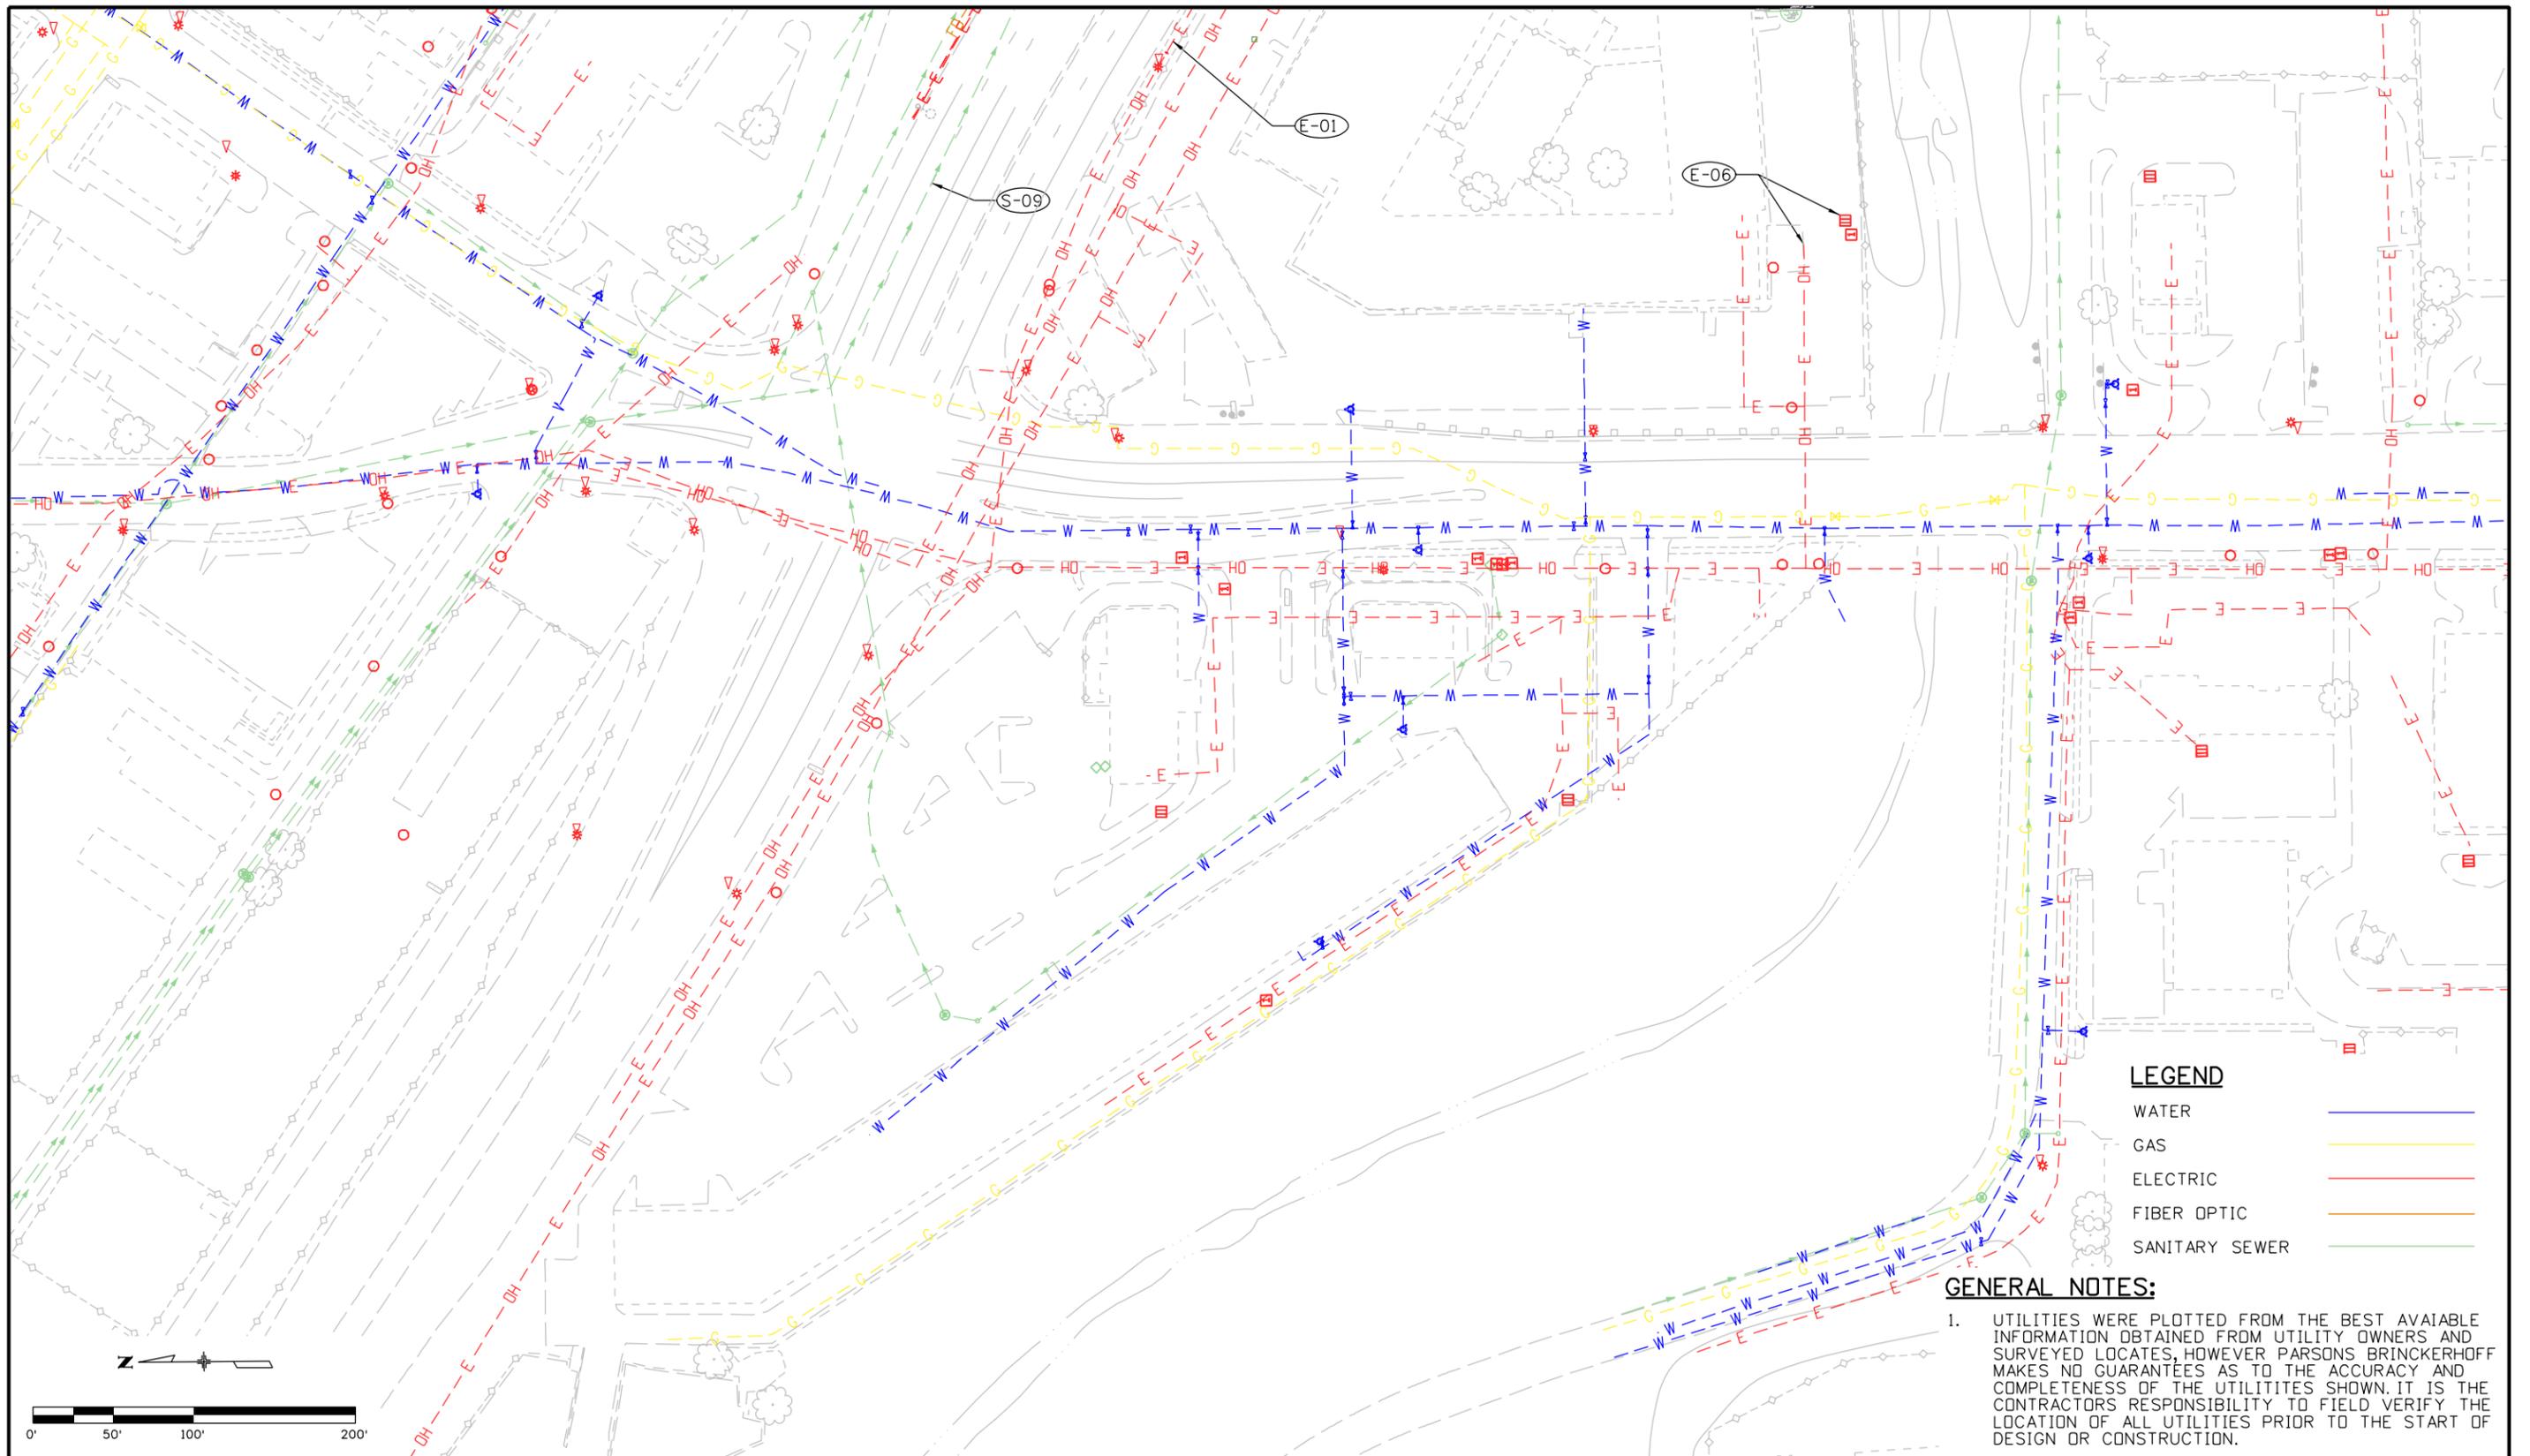

LEGEND

WATER	
GAS	
ELECTRIC	
FIBER OPTIC	
SANITARY SEWER	

GENERAL NOTES:

- UTILITIES WERE PLOTTED FROM THE BEST AVAILABLE INFORMATION OBTAINED FROM UTILITY OWNERS AND SURVEYED LOCATES, HOWEVER PARSONS BRINCKERHOFF MAKES NO GUARANTEES AS TO THE ACCURACY AND COMPLETENESS OF THE UTILITIES SHOWN. IT IS THE CONTRACTORS RESPONSIBILITY TO FIELD VERIFY THE LOCATION OF ALL UTILITIES PRIOR TO THE START OF DESIGN OR CONSTRUCTION.

Print Date: 5/28/2014	
File Name: Pothole Sheet 7	
Horiz. Scale: 1:100	Vert. Scale:
Unit Information	Unit Leader Initials
555 17th Street Suite 500 Denver, CO 80202	

Sheet Revisions		
Date:	Comments	Init.

Colorado Department of Transportation

 1480 Quail Lake Loop, Suite A
 Colorado Springs, CO 80906
 Phone: 719-634-2323 FAX: 719-227-3298
Region 2 **DMW**

As Constructed
No Revisions:
Revised:
Void:

UTILITY POTHOLES MAP SHEET 7 OF 7			
Designer:	XXXXXXXX	Structure	
Detailer:	XXXXXXXX	Numbers	
Subset:	_SG	Subset Sheets:	_SN of _SO

Project No./Code
IM 0252-423
19039
Sheet Number _ON