

# EXHIBIT B UTILITY DESIGN SHEET

PROJECT IM 0252-423

Utility Co. #	Conflict #
	T-01

Utility Owner: City of Colorado Springs Traffic  Public  Private

## SECTION TO BE COMPLETED PRIOR TO NEGOTIATION MEETING

### Existing Condition See Utility Map for conflicts to T-01


- General Location \_\_\_\_\_
- Utility type:  Electric  Gas  Communications  Water  Sanitary  Cable TV  Irr. Canal  
 Other \_\_\_\_\_
- Location by:  Utility plat maps; Field located and surveyed:  Yes  No; Pothole:  Yes  No  
If pothole, # \_\_\_\_\_ from:  CDOT pothole or  DBC pothole HCL used: \_\_\_\_\_  
Station: 90+LT/711+RT to Station: 130+LT/721+LT Dist. from HCL: \_\_\_\_\_ Rt. / Lt. \_\_\_\_\_
- Utility size & type of materials: 3 – 2” Conduits with Fiber Optic cable from 8th St. South to S. Project limits.
- Environmental Concerns: \_\_\_\_\_
- Encased:  No  Yes, if so size & material: \_\_\_\_\_  
This section completed by DBC Rep.: \_\_\_\_\_ Date: \_\_\_\_\_

## SECTION TO BE COMPLETED AT NEGOTIATION MEETING

### Proposed Resolution

- Recommendation:  left alone  modified  removed  relocated  upgraded  abandoned in place  
Conflict with: \_\_\_\_\_
- This utility may be modified/relocated to: \_\_\_\_\_  
Station: \_\_\_\_\_ to Station: \_\_\_\_\_ Dist. from HCL: \_\_\_\_\_ Rt./Lt. \_\_\_\_\_
- Utility in:  CDOT ROW  other public ROW  Easement (attach copy)  other \_\_\_\_\_
- Who will do the Utility Relocation Plan:  Utility Company ( UC )  Design/Build Contractor (DBC)
- Who will do the construction:  Utility Company ( UC )  Design/Build Contractor (DBC)
- UC to perform inspection?  No  Yes, if so conditions: \_\_\_\_\_
- Number of days required for prior notification by DBC for construction by UC: \_\_\_\_\_ days
- Number of days required by UC or DBC to complete Utility Relocation Plan: \_\_\_\_\_ days; Construction: \_\_\_\_\_ days.
- Any construction details unique to this location?  No  Yes, if yes describe: \_\_\_\_\_
- Utility can be disconnected for: \_\_\_\_\_ days/hours.
- Other proposed action: \_\_\_\_\_
- Contractor Drawings confirming conflict must be attached  
This section completed by: Utility Co. \_\_\_\_\_ Date: \_\_\_\_\_ DBC \_\_\_\_\_ Date: \_\_\_\_\_

Padlak 3:56:16 PM p:\ABOPWINT01\wilsonco.com\Wilson\_Proj\Projects\Documents\B100-TRN\CDOT\13-100-312-01\_125\_Cimarron\_Interch\19039\Utilities\Drawings\ITS\_Site\_Plan

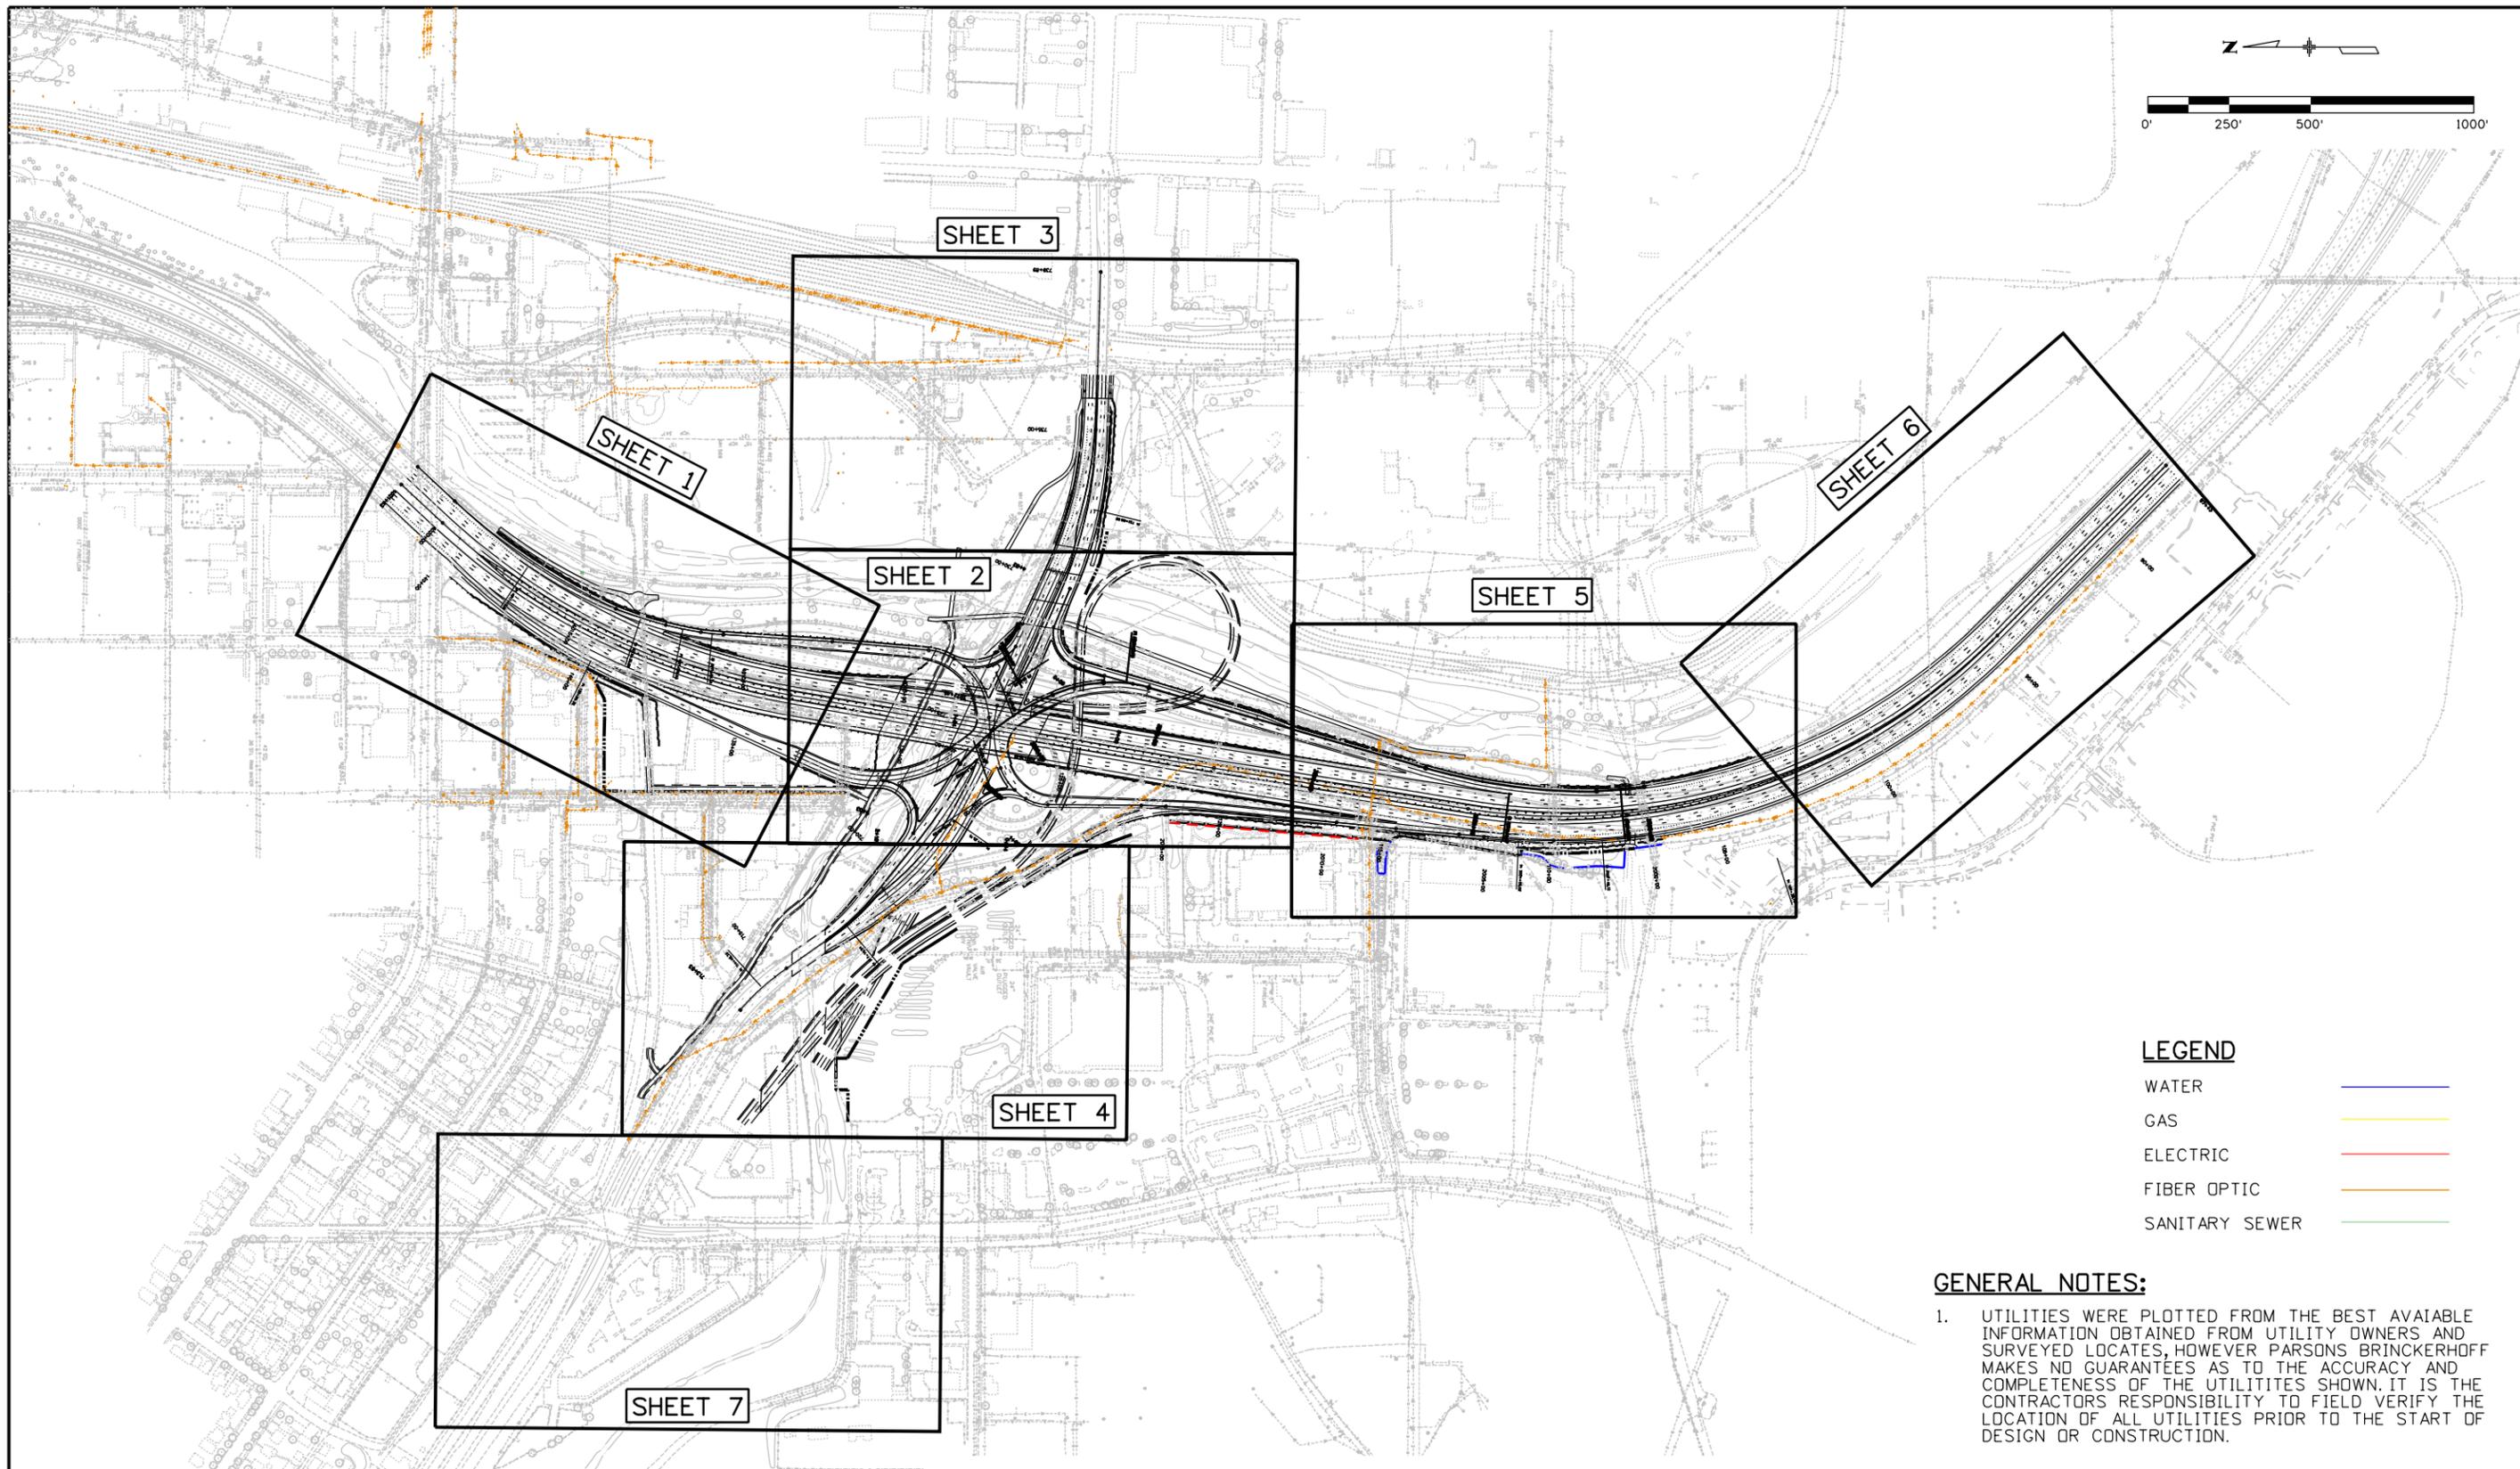

**LEGEND**


WATER	
GAS	
ELECTRIC	
FIBER OPTIC	
SANITARY SEWER	

**GENERAL NOTES:**

- UTILITIES WERE PLOTTED FROM THE BEST AVAILABLE INFORMATION OBTAINED FROM UTILITY OWNERS AND SURVEYED LOCATES, HOWEVER PARSONS BRINCKERHOFF MAKES NO GUARANTEES AS TO THE ACCURACY AND COMPLETENESS OF THE UTILITIES SHOWN. IT IS THE CONTRACTOR'S RESPONSIBILITY TO FIELD VERIFY THE LOCATION OF ALL UTILITIES PRIOR TO THE START OF DESIGN OR CONSTRUCTION.

Print Date: 4/17/2014 File Name: ITS Site Plan Horiz. Scale: 1:500      Vert. Scale: Unit Information      Unit Leader Initials 555 17th Street Suite 500 Denver, CO 80202	<table border="1" style="width: 100%; border-collapse: collapse;"> <thead> <tr> <th colspan="3">Sheet Revisions</th> </tr> <tr> <th>Date:</th> <th>Comments</th> <th>Init.</th> </tr> </thead> <tbody> <tr> <td> </td> <td> </td> <td> </td> </tr> <tr> <td> </td> <td> </td> <td> </td> </tr> <tr> <td> </td> <td> </td> <td> </td> </tr> </tbody> </table>	Sheet Revisions			Date:	Comments	Init.										Colorado Department of Transportation  1480 Quail Lake Loop, Suite A Colorado Springs, CO 80906 Phone: 719-634-2323    FAX: 719-227-3298 Region 2      DMW	<table border="1" style="width: 100%; border-collapse: collapse;"> <thead> <tr> <th>As Constructed</th> </tr> </thead> <tbody> <tr> <td>No Revisions:</td> </tr> <tr> <td>Revised:</td> </tr> <tr> <td>Void:</td> </tr> </tbody> </table>	As Constructed	No Revisions:	Revised:	Void:	<table border="1" style="width: 100%; border-collapse: collapse;"> <thead> <tr> <th colspan="4">UTILITY ITS SITE PLAN</th> </tr> </thead> <tbody> <tr> <td>Designer:</td> <td>XXXXXXXX</td> <td>Structure Numbers</td> <td> </td> </tr> <tr> <td>Detailer:</td> <td>XXXXXXXX</td> <td> </td> <td> </td> </tr> <tr> <td>Subset:</td> <td>_SG</td> <td>Subset Sheets: _SN of _SD</td> <td> </td> </tr> </tbody> </table>	UTILITY ITS SITE PLAN				Designer:	XXXXXXXX	Structure Numbers		Detailer:	XXXXXXXX			Subset:	_SG	Subset Sheets: _SN of _SD		<table border="1" style="width: 100%; border-collapse: collapse;"> <thead> <tr> <th>Project No./Code</th> </tr> </thead> <tbody> <tr> <td>IM 0252-423</td> </tr> <tr> <td>19039</td> </tr> <tr> <td>Sheet Number    _ON</td> </tr> </tbody> </table>	Project No./Code	IM 0252-423	19039	Sheet Number    _ON
Sheet Revisions																																												
Date:	Comments	Init.																																										
As Constructed																																												
No Revisions:																																												
Revised:																																												
Void:																																												
UTILITY ITS SITE PLAN																																												
Designer:	XXXXXXXX	Structure Numbers																																										
Detailer:	XXXXXXXX																																											
Subset:	_SG	Subset Sheets: _SN of _SD																																										
Project No./Code																																												
IM 0252-423																																												
19039																																												
Sheet Number    _ON																																												

Padlak 4:14:45 PM \\ABQPWINT01.wilsonco.com\Wilson\Projects\Documents\8100-TRN\CDDT\13-100-312-01\_125\_Cimarron\_Utillites\Drawings\ITS\_Sheet 1 CoSpgsTraffic

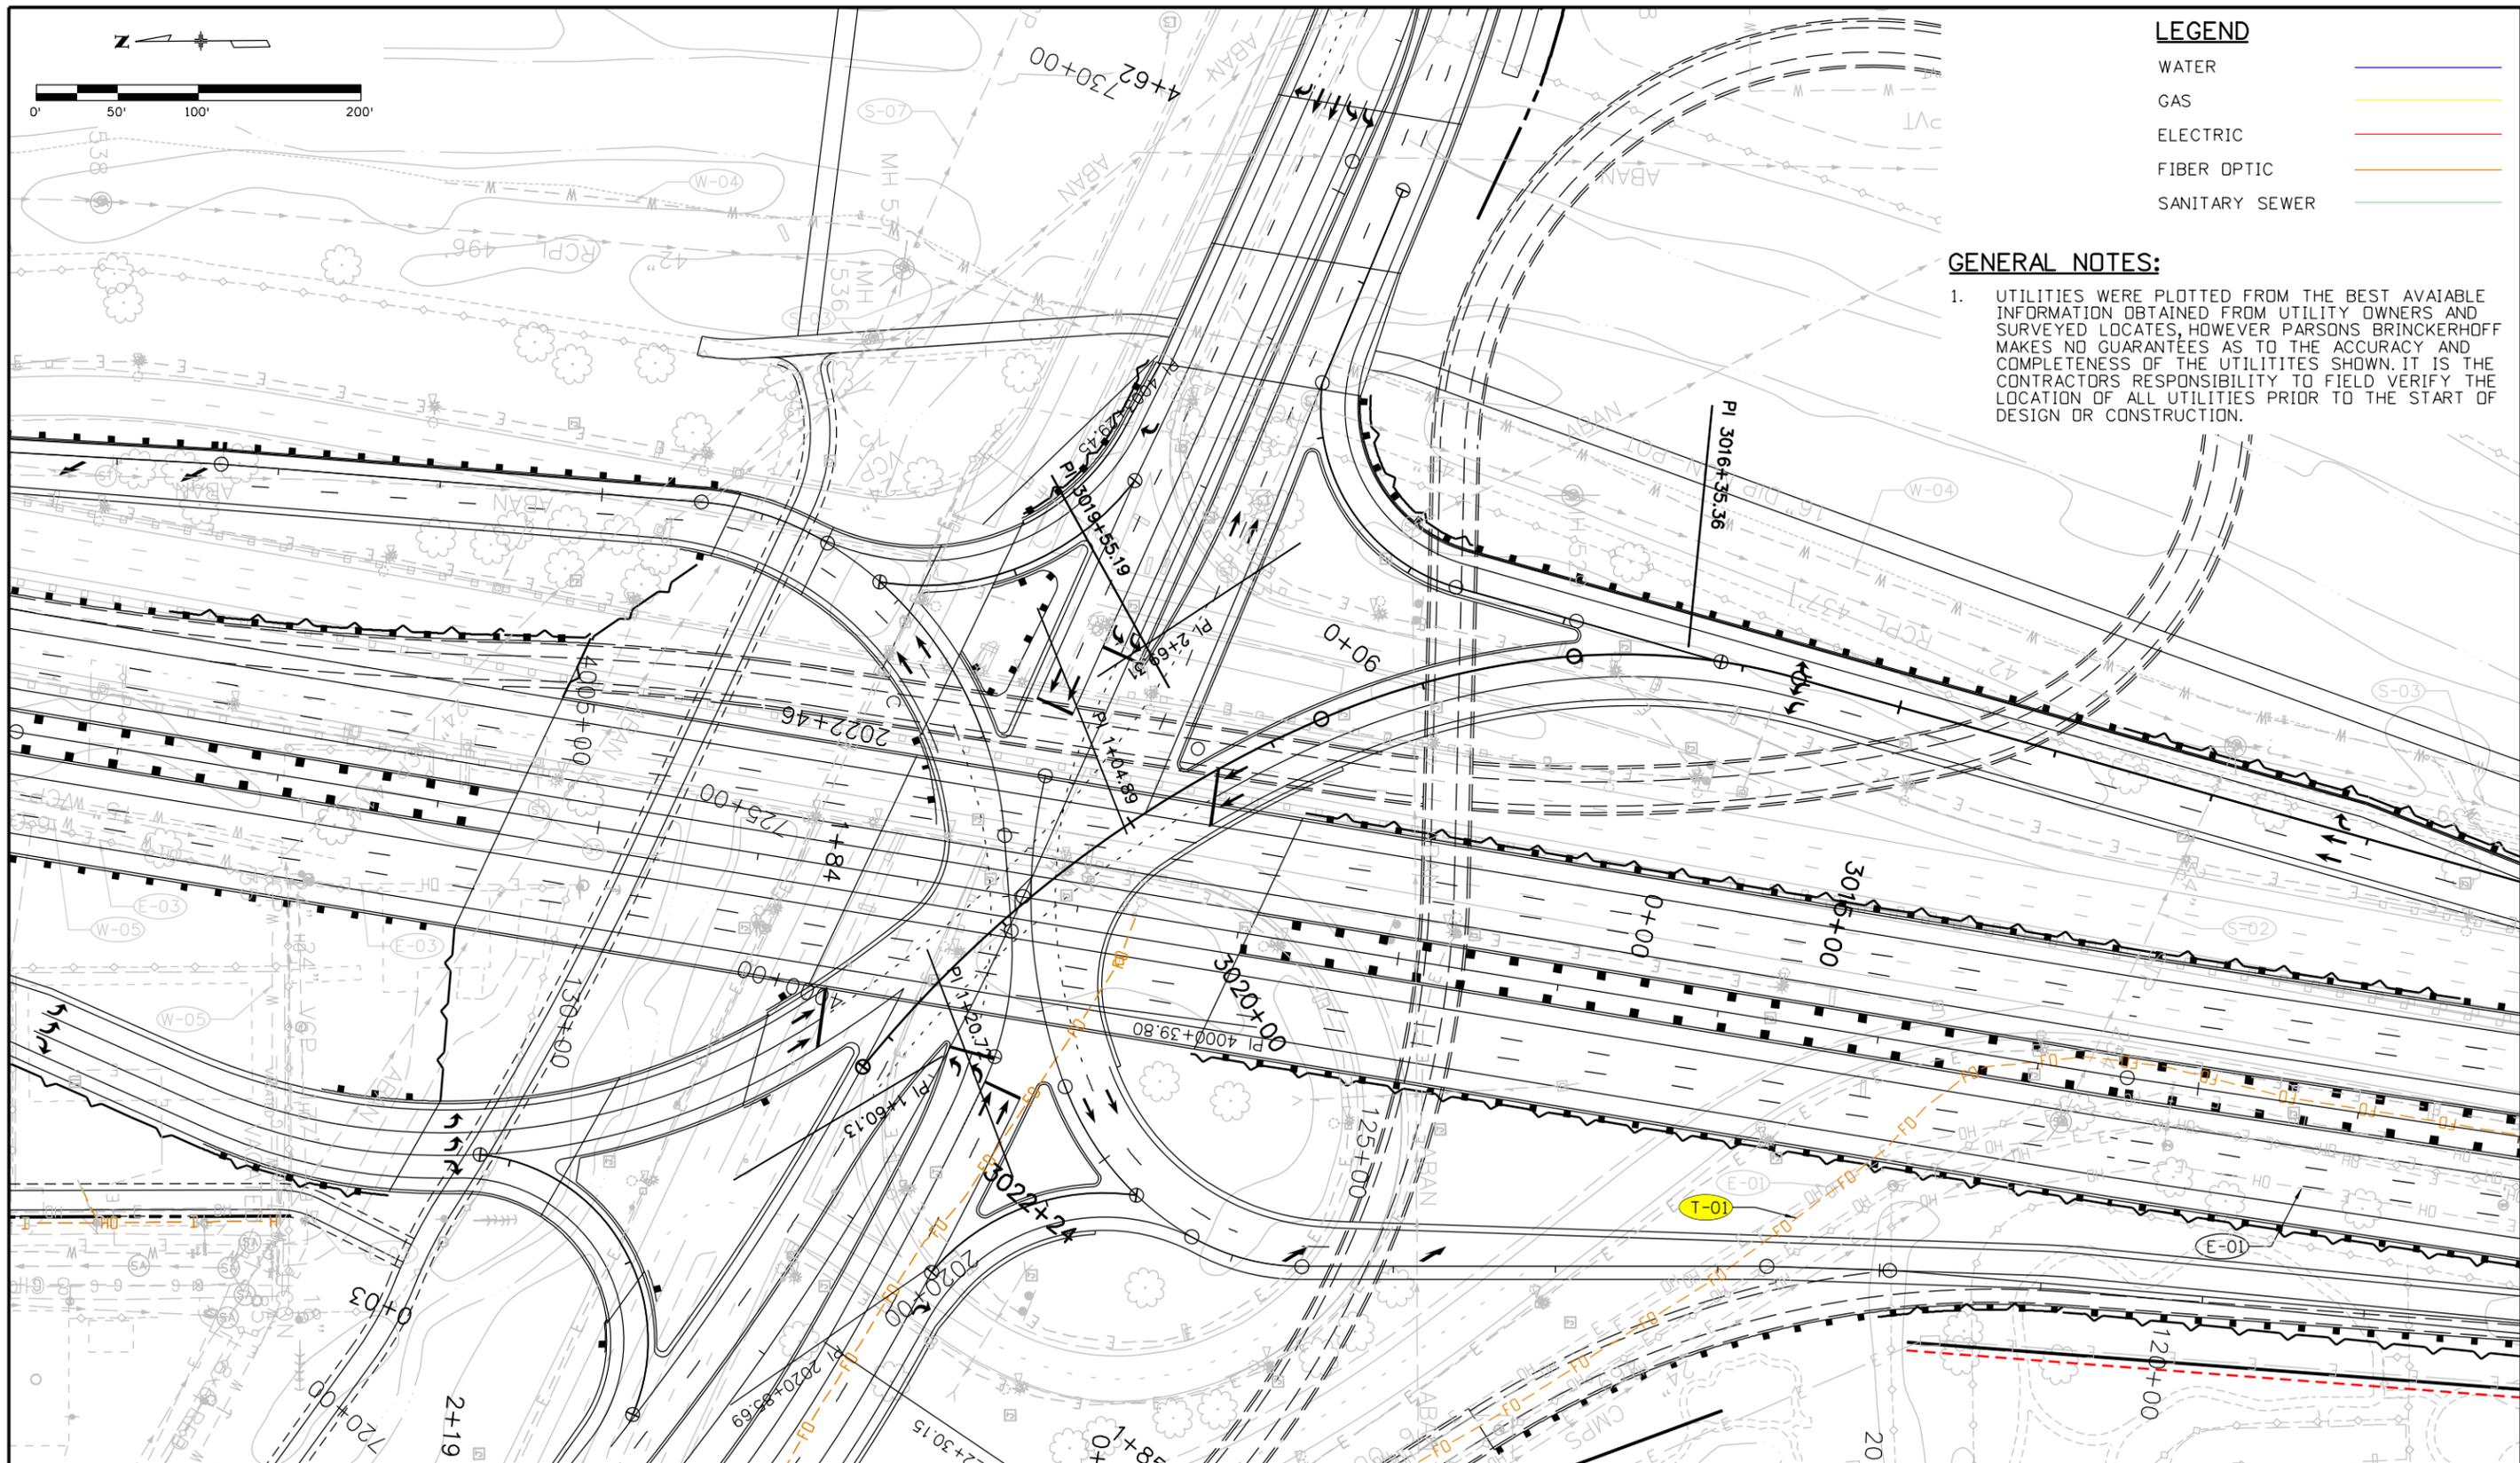

LEGEND	
WATER	
GAS	
ELECTRIC	
FIBER OPTIC	
SANITARY SEWER	

**GENERAL NOTES:**

- UTILITIES WERE PLOTTED FROM THE BEST AVAILABLE INFORMATION OBTAINED FROM UTILITY OWNERS AND SURVEYED LOCATES, HOWEVER PARSONS BRINCKERHOFF MAKES NO GUARANTEES AS TO THE ACCURACY AND COMPLETENESS OF THE UTILITIES SHOWN. IT IS THE CONTRACTORS RESPONSIBILITY TO FIELD VERIFY THE LOCATION OF ALL UTILITIES PRIOR TO THE START OF DESIGN OR CONSTRUCTION.

Print Date: 4/17/2014	
File Name: ITS Sheet 1 CoSpgsTraffic	
Horiz. Scale: 1:100	Vert. Scale:
Unit Information	Unit Leader Initials
	555 17th Street Suite 500 Denver, CO 80202

Sheet Revisions		
Date:	Comments	Init.

Colorado Department of Transportation  
  
 1480 Quail Lake Loop, Suite A  
 Colorado Springs, CO 80906  
 Phone: 719-634-2323 FAX: 719-227-3298  
 Region 2 DMW

<b>As Constructed</b>
No Revisions:
Revised:
Void:

<b>ITS COLORADO SPRINGS TRAFFIC</b>			
SHEET 1 OF 3			
Designer:	XXXXXXXX	Structure	
Detailer:	XXXXXXXX	Numbers	
Subset:	_SG	Subset Sheets:	_SN of _SO

<b>Project No./Code</b>
IM 0252-423
19039
Sheet Number <b>_ON</b>



